 



| | | |
|--|-------|---------------------------------|
| Project: Tourism Sector Development Project in the Hashemite Kingdom of Jordan | | |
| Executing Agency The Ministry of Tourism and Antiquities The Ministry of Planning | | |
| SUB-PROJECT: Karak Tourism Development Project Upper Observation Point | | |
| Note: This detailed design has been executed by a team of consultants as shown below in accordance with the agreement between Japan International Cooperation Agency (JICA) and JICA Study Team. The copyright of this drawing rests with JICA. | | |
|  | | |
| Designed by: Japan International Cooperation Agency (JICA) JICA Study Team: Joint Venture of Pacific Consultants International and Yamasa Sekkei Inc. Subcontracted Local Consultant: | | |
|  | | |
| Date: | June | 2000 |
| GROUND FLOOR PLAN Drawing Title | | |
| Scale: | 1:100 | Drawing No: UOP.A-008 |

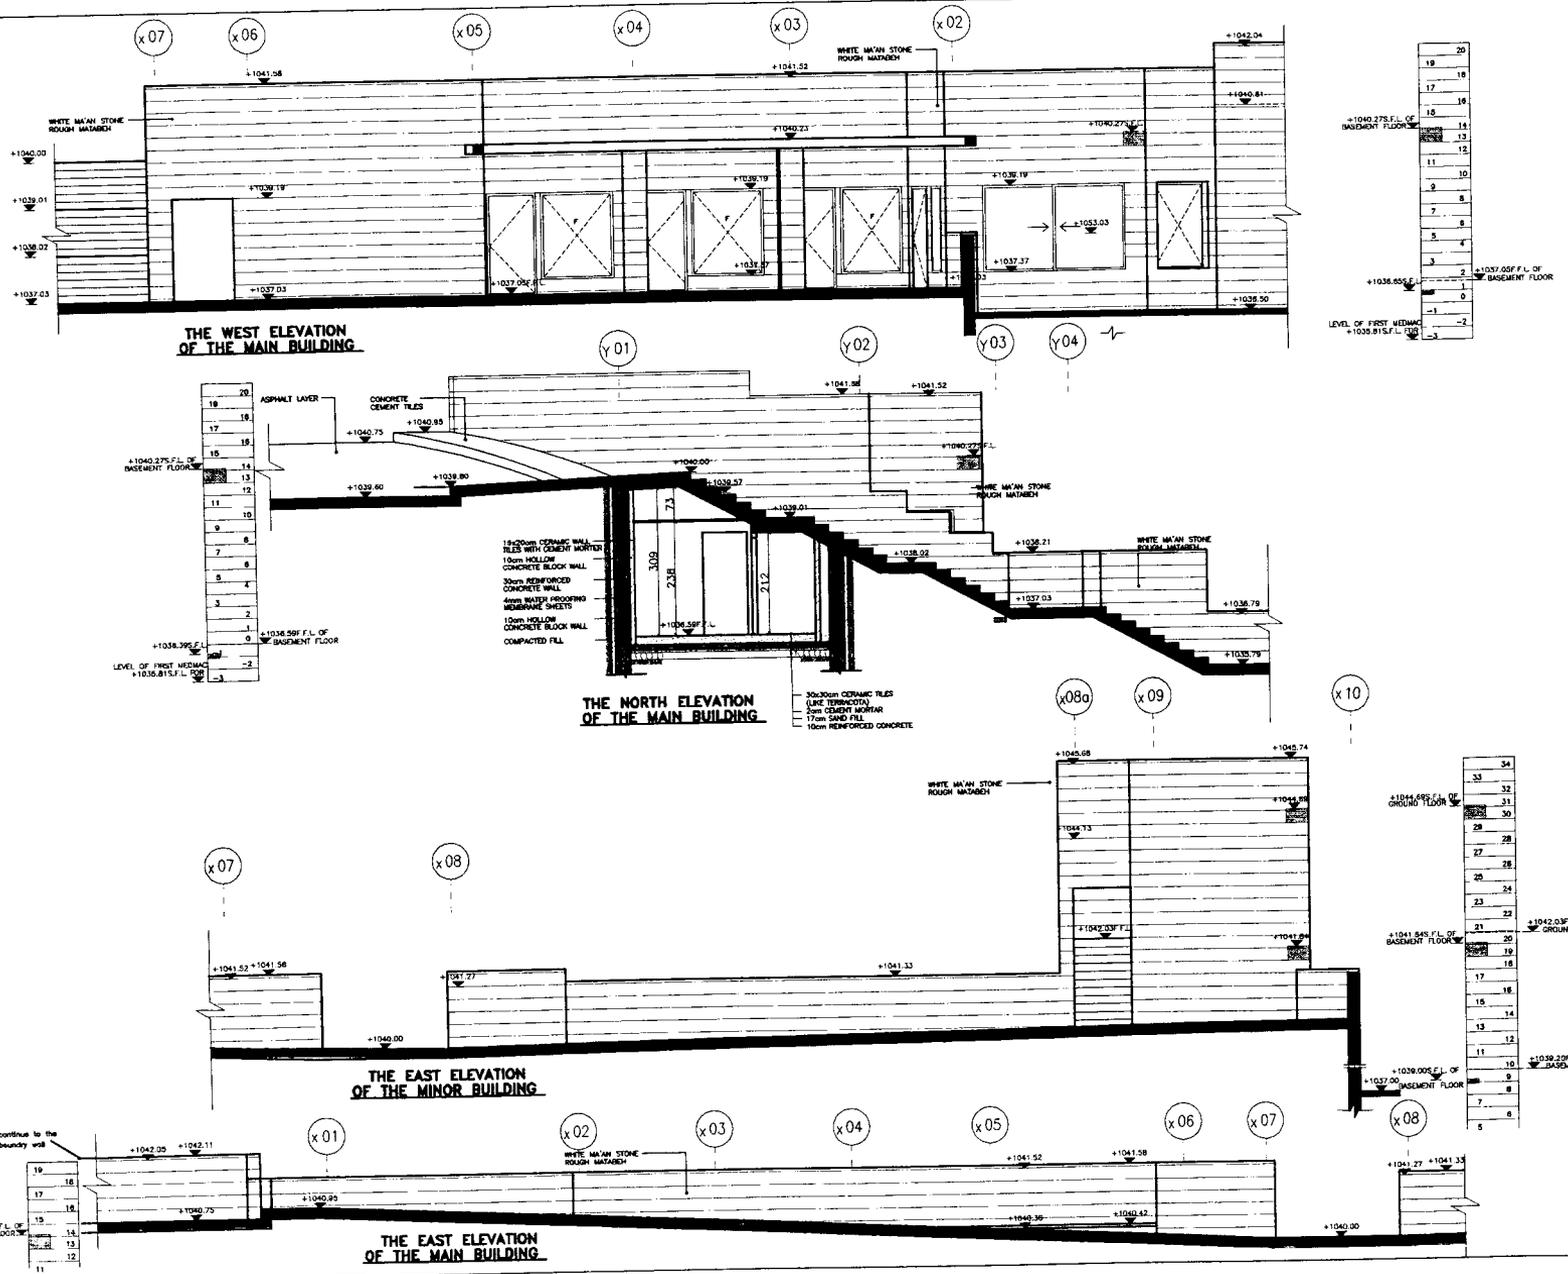

Project:
Tourism Sector Development Project
in the Hashemite Kingdom of Jordan

Executing Agency
The Ministry of Tourism and Antiquities
The Ministry of Planning

SUB-PROJECT:
Karak Tourism Development Project
Upper Observation Point

Note:
This detailed design has been executed by a team of consultants as shown below in accordance with the agreement between Japan International Cooperation Agency (JICA) and JICA Study Team.
The copyright of this drawing rests with JICA.

NOTE:
- STONE CLADDING FOR BUILDING IS OF MA'AN STONE (10mm) WITH CEMENT MORTAR (ROUGH MATABEH).
- STONE CLADDING FOR WALLS AND RETAINING WALLS IS OF MA'AN STONE (5cm) WITH CEMENT MORTAR (ROUGH MATABEH).
- VENTILATION OPENING IN FACADES TO BE COORDINATED WITH MECHANICAL ENGINEER.

Designed by:
Japan International Cooperation Agency (JICA)
JICA Study Team:
Joint Venture of
Pacific Consultants International and
Yamamoto Sekkei Inc.
Subcontracted Local Consultant:

consolidated consultants
ENGINEERING & ARCHITECTURE
Tel: 9622571 - Fax: 9622288 - AMMAN - JORDAN

Date: June 2000

ELEVATIONS

Drawing Title:

Scale: 1:50 Drawing No.: UOP-A-010

Project:
Tourism Sector Development Project
in the Hashemite Kingdom of Jordan

Executing Agency
The Ministry of Tourism and Antiquities
The Ministry of Planning

SUB-PROJECT:
Karak Tourism Development Project
Upper Observation Point

Note:
This detailed design has been executed by a team of consultants as shown below in accordance with the agreement between Japan International Cooperation Agency (JICA) and JICA Study Team.
The copyright of this drawing rests with JICA.

NOTE:
- STONE CLADDING FOR BUILDING IS OF MA'AN STONE (10cm) WITH CEMENT MORTAR. (ROUGH MATAHDI)
- STONE CLADDING FOR WALLS AND RETAINING WALLS IS OF MA'AN STONE (5cm) WITH CEMENT MORTAR. (ROUGH MATAHDI).

Designed by:
Japan International Cooperation Agency (JICA)
JICA Study Team:
Joint Venture of Pacific Consultants International and Yamasaitei Sekkei Inc.
Subcontracted Local Consultant:


consolidated consultants
PACIFIC CONSULTANTS INTERNATIONAL
YAMASAITSEI SEKKEI INC.
Tel: 912277 - Fax: 912280 - AMM - JORDAN

Date: June 2000

ELEVATIONS

Drawing Title:

Scale: 1:50 Drawing No.: UOP.A-011

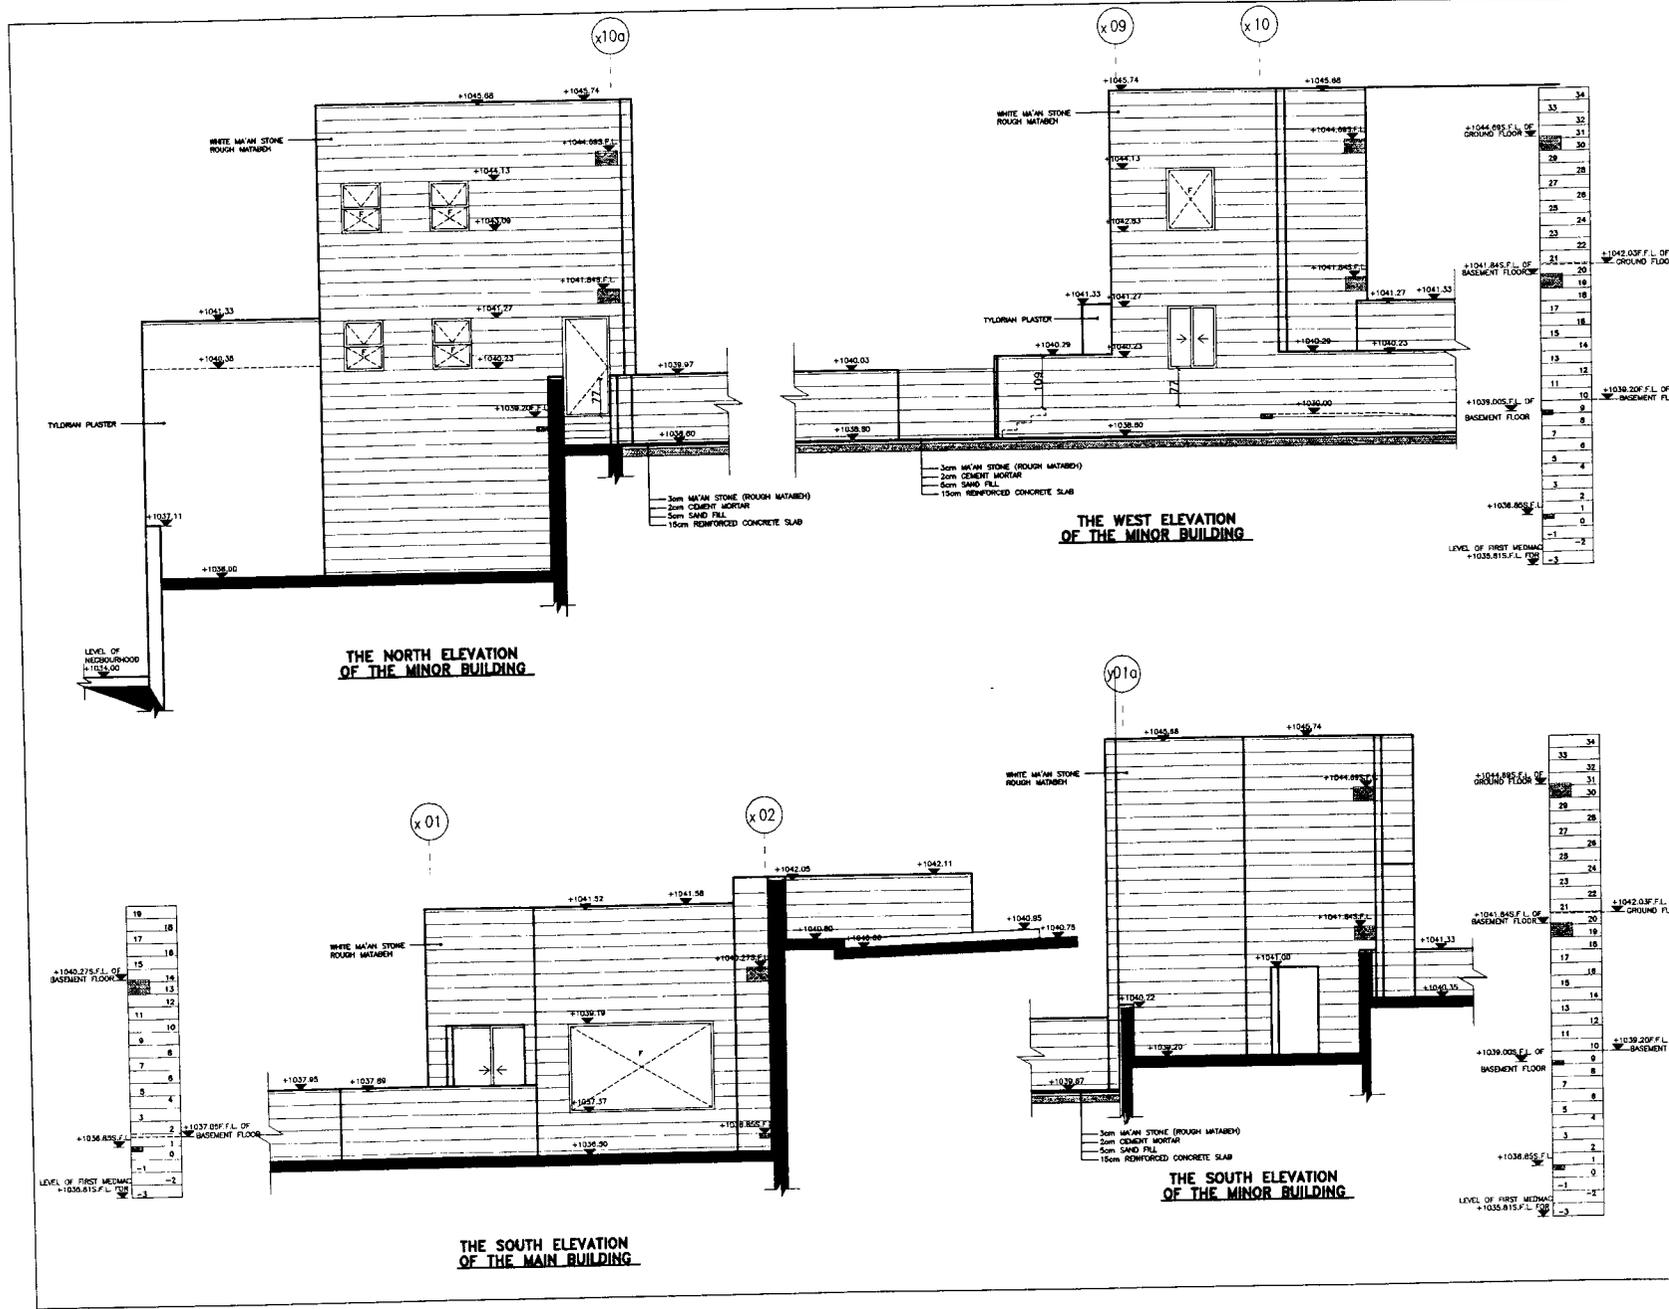

Project:
Tourism Sector Development Project
in the Hashemite Kingdom of Jordan

Executing Agency
The Ministry of Tourism and Antiquities
The Ministry of Planning

SUB-PROJECT:
Karak Tourism Development Project
Upper Observation Point

Note:
This detailed design has been executed by
a team of consultants as shown below in
accordance with the agreement between
Japan International Cooperation Agency
(JICA) and JICA Study Team.
The copyright of this drawing rests with
JICA.

LEGEND:

- AVY 02 AIR ASSISTANCE VALVE
- CO CLEAN OUT
- FD FLOOR DRAIN
- MM MARBLE
- UPVC UNPLASTICIZED POLYVINYL CHLORIDE
- CS CROSSLINKED POLYETHYLENE
- VT UNDER TILE
- UP UPSTAIR
- OP DOWN PIPE
- TA TO ABOVE
- TD FROM BELOW
- TS TO BELOW
- MS MESH REINFORCEMENT BOX
- EMV ELECTRIC HOT WATER HEATER CAPACITY 50 LTR
- EMV ELECTRIC HOT WATER HEATER CAPACITY 10 LTR
- ESP WATER METER
- MS WATER METER
- LT UP/MS COLD WATER SUPPLY
- LT DOWN/MS COLD WATER SUPPLY
- HT/MS CROSS LINKED POLYETHYLENE
- HT/MS CROSSLINKED POLYETHYLENE
- HT/MS DRINKING WATER
- HT/MS HOT WATER SUPPLY
- HT/MS FIRE EXTINGUISHER (BY CODE)
- HT/MS CONCRETE PIPE
- HT/MS WATER AUTHORITY OF JORDAN
- HT/MS HIGH DENSITY POLY ETHYLENE

SYMBOLS:

- W SWIMMER
- FD FLOOR DRAIN
- CO CLEAN OUT
- OP DOWN PIPE
- LT COLD WATER SUPPLY
- OP DOWN PIPE
- HT HOT WATER SUPPLY

GENERAL NOTES:

- ALL DRAINAGE PIPES SHALL BE UPVC CLASS II BAR
- ALL UNDER TILE DOMESTIC WATER PIPES SHALL BE UPVC UNLESS OTHERWISE STATED.
- ALL MARBLE COVERS SHALL BE MEDIAN CUT.
- EXTRACT FANS SHALL BE ACCOMPANIED WITH AUTOMATIC SHUTTERS.
- CONTRACTOR SHALL COMPLY WITH BHA REGULATIONS FOR MARBLE, PIPE CROSSING THE STREET, ETC.
- CONTRACTOR SHALL COORDINATE ALL NEW WORKS WITH BHA PRIOR TO INSTALLATION.

Designed by:
Japan International Cooperation Agency (JICA)
JICA Study Team:
Joint Venture of Pacific Consultants International and Yamashita Sekkei Inc.
Subcontracted Local Consultant:

consolidated consultants
ENGINEERING & ARCHITECTURE
Tel: 912277 - Fax: 491230 - AMMAN - JORDAN

Date: June 2000


GROUND & BASEMENT FLOORS
WATER, DRAINAGE
& ROOF LAYOUTS

Drawing Title:


Scale: 1/100

Drawing No.:


UOP.M-001

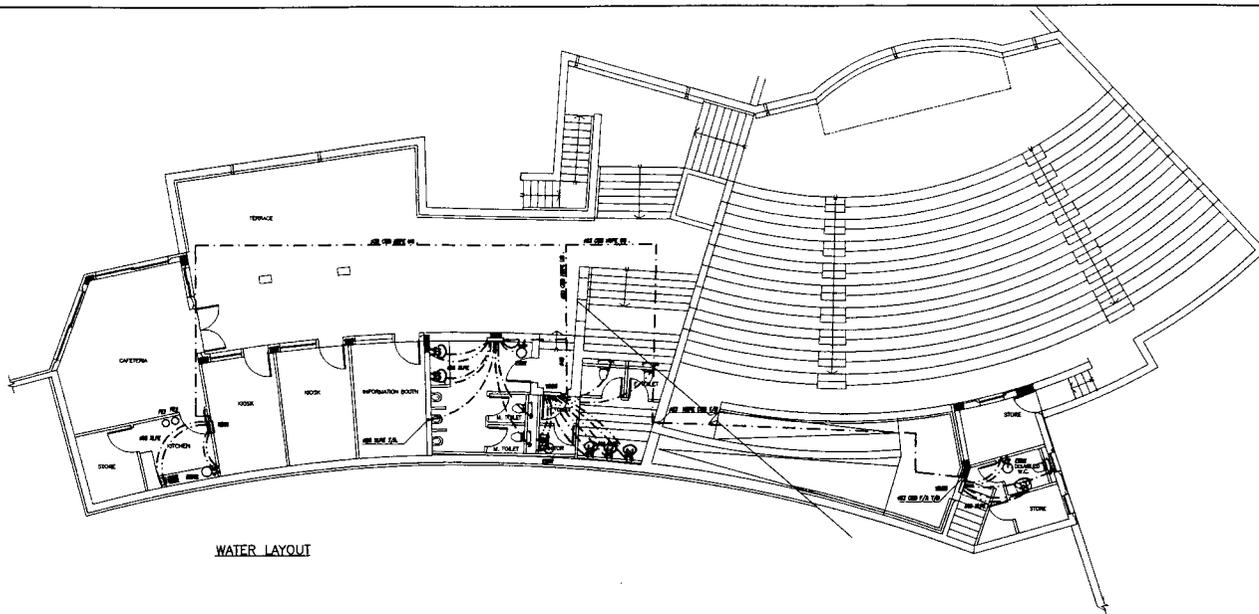


WATER LAYOUT

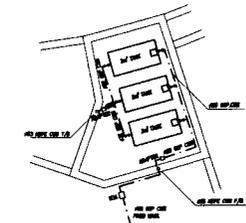


WATER LAYOUT

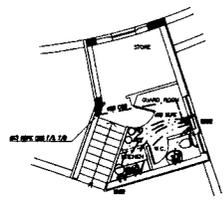

WATER LAYOUT

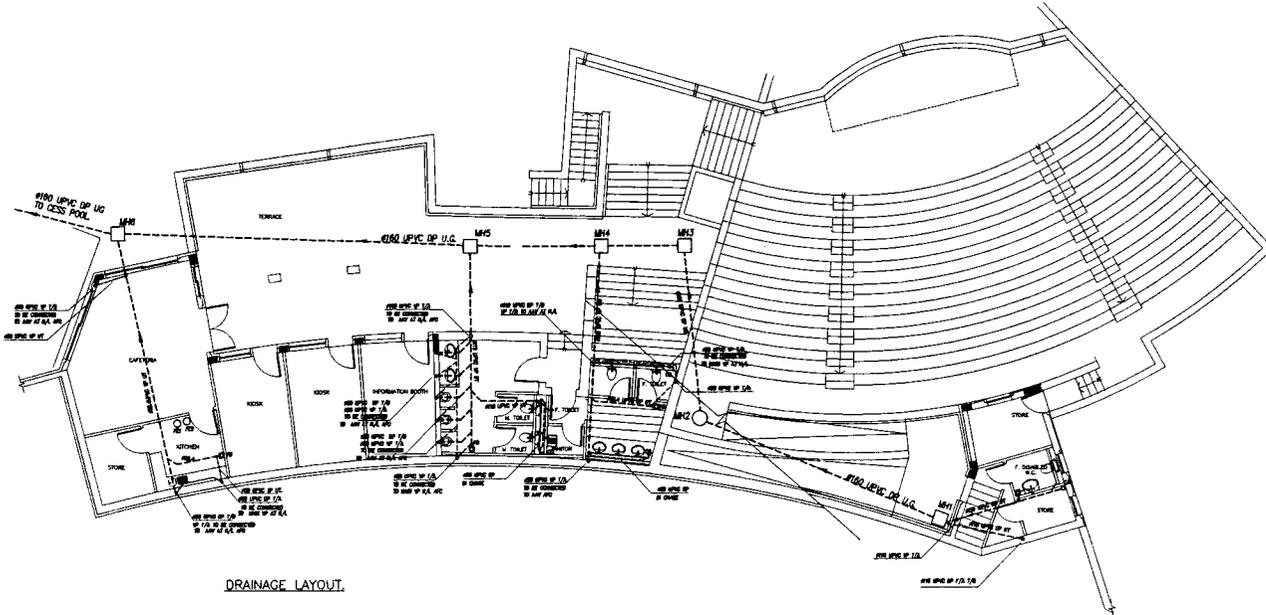


DRAINAGE LAYOUT

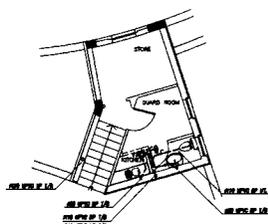

DRAINAGE LAYOUT

| MANHOLE SCHEDULE. | | | | | |
|-------------------|-------------|--------------|-----------|----------|---------|
| NO. | COVER LEVEL | INVERT LEVEL | DEPTH (m) | SIZE (m) | NOTES. |
| MH1 | 1036.20 | 1036.60 | 600 | 800x800 | - |
| MH2 | 1036.10 | 1037.25 | 1670 | #600 | DR.LIN. |
| MH3 | 1037.03 | 1038.51 | 520 | 800x800 | - |
| MH4 | 1037.03 | 1036.43 | 800 | 800x800 | - |
| MH5 | 1037.03 | 1036.33 | 700 | 800x800 | - |
| MH6 | 1037.03 | 1036.13 | 900 | 800x800 | - |

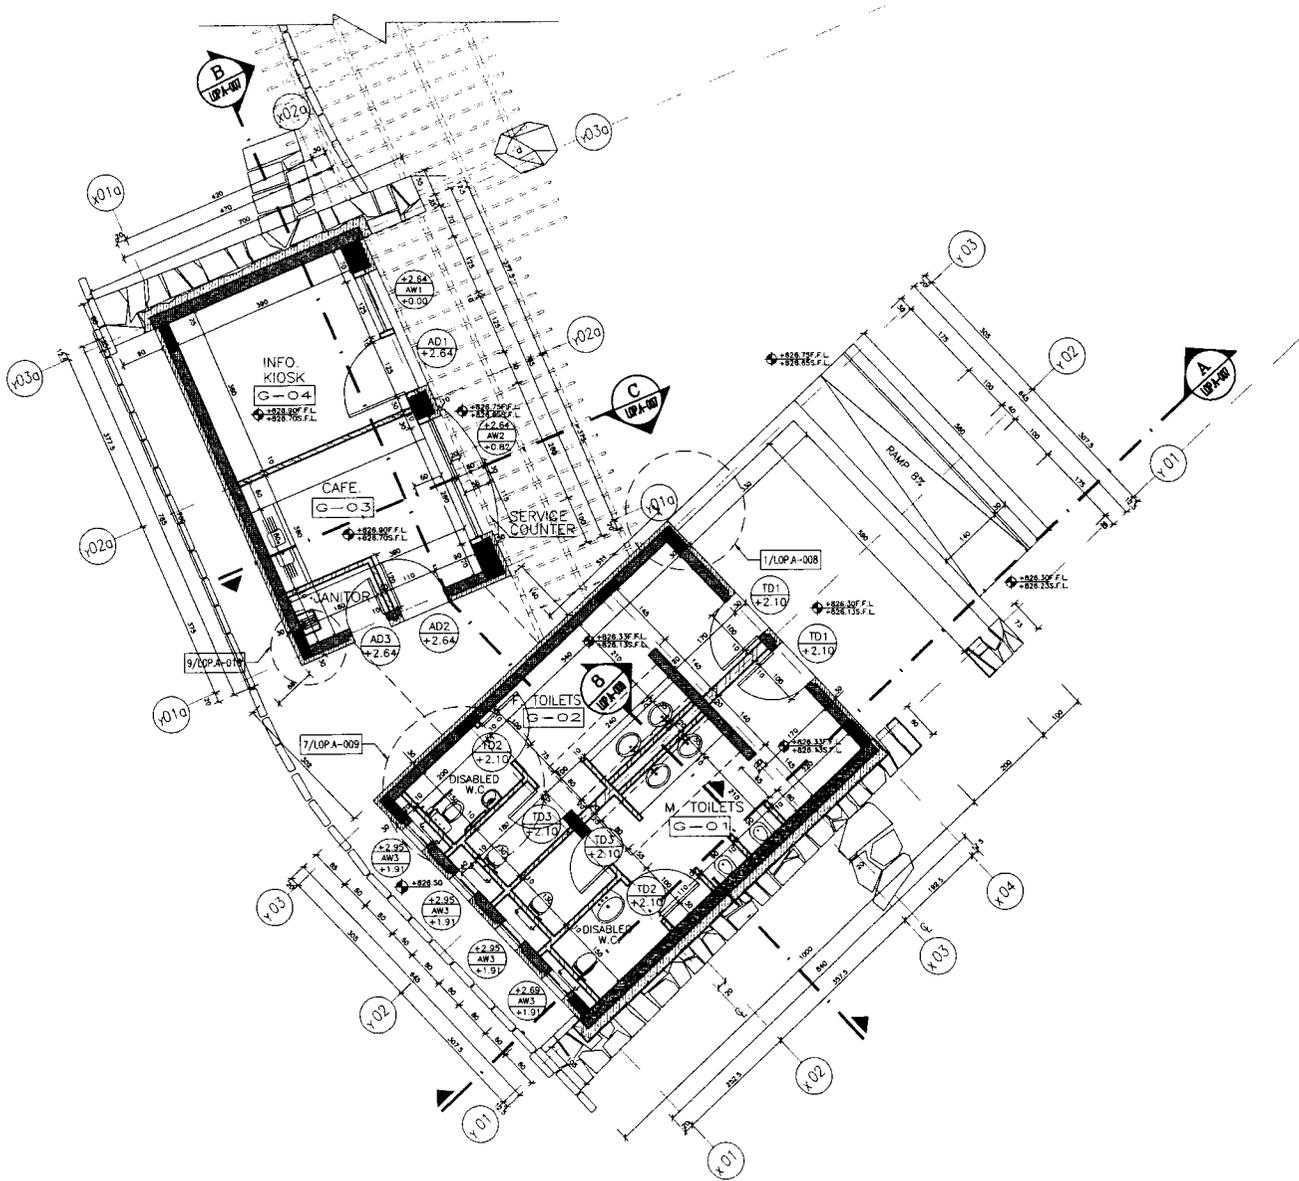

Project:
Tourism Sector Development Project
in the Hashemite Kingdom of Jordan

Executing Agency
The Ministry of Tourism and Antiquities
The Ministry of Planning

SUB-PROJECT:
Karak Tourism Development Project
Lower Observation Point

Note:
This detailed design has been executed by
a team of consultants as shown below in
accordance with the agreement between
Japan International Cooperation Agency
(JICA) and JICA Study Team.
The copyright of this drawing rests with
JICA.




Designed by:
Japan International Cooperation
Agency (JICA)
JICA Study Team:
Joint Venture of
Pacific Consultants International and
Yamamoto Sekkei Inc.
Subcontracted Local Consultant:

consolidated consultants
Tel: 4813777 - Fax: 4813380 - AMMAN - JORDAN


Date: June 2000

GROUND FLOOR PLAN
Drawing Title:


Scale: 1/50
Drawing No.: LOP A-005

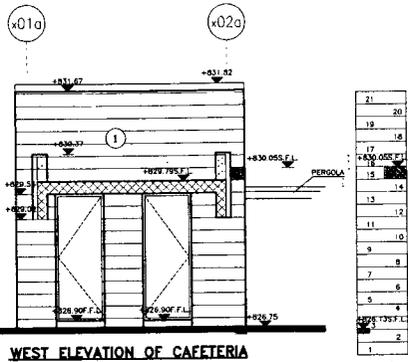


WEST ELEVATION OF CAFETERIA

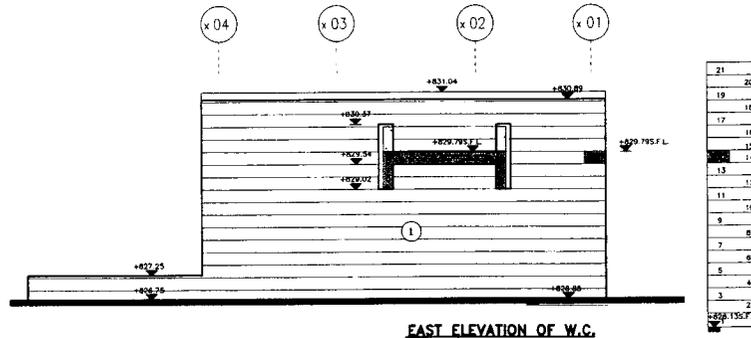


EAST ELEVATION OF W.C.

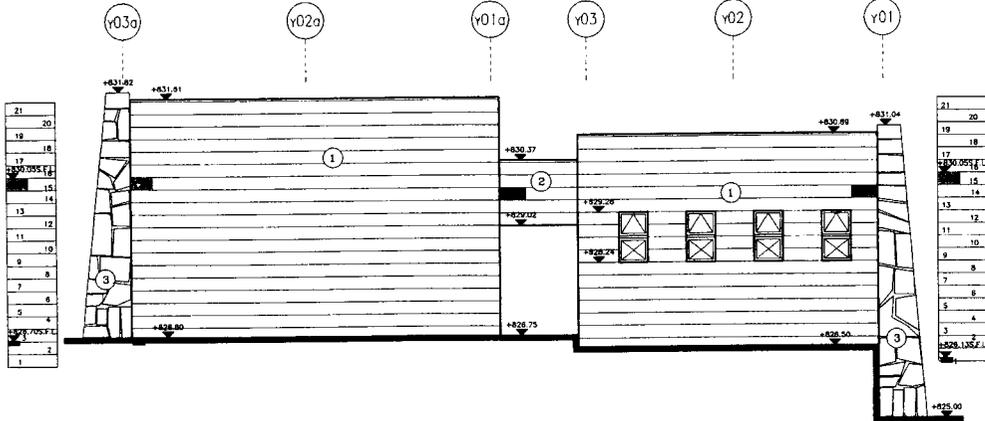


NORTH ELEVATION

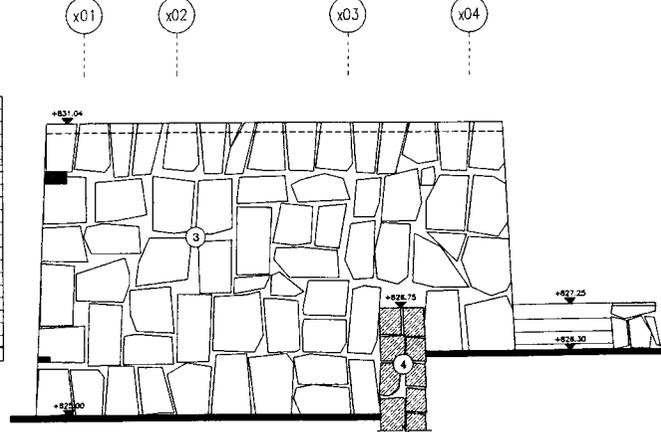

WEST ELEVATION OF W.C.

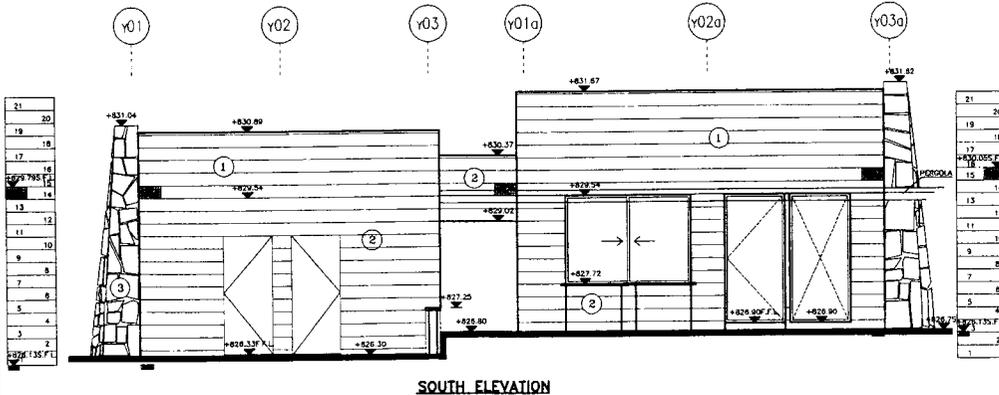

SOUTH ELEVATION

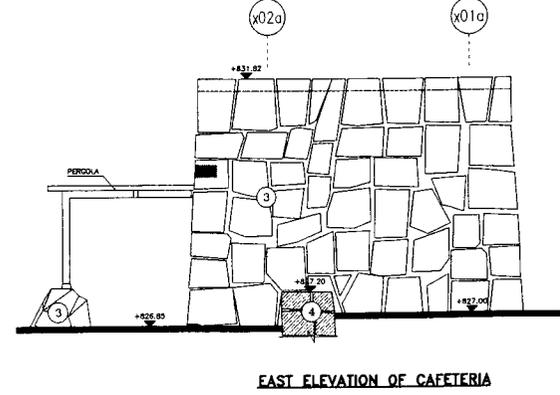

EAST ELEVATION OF CAFETERIA

Project:
Tourism Sector Development Project
in the Hashemite Kingdom of Jordan

Executing Agency
The Ministry of Tourism and Antiquities
The Ministry of Planning

SUB-PROJECT:
Karak Tourism Development Project
Lower Observation Point

Note:
This detailed design has been executed by
a team of consultants as shown below in
accordance with the agreement between
Japan International Cooperation Agency
(JICA) and JICA Study Team.
The copyright of this drawing rests with
JICA.

LEGEND:
① : MA'AN WHITE STONE COURSES
② : KARAK BLACK STONE COURSES
③ : KARAK BLACK STONE (BIG ROUGH CUTS)
④ : WHITE RUBBLE STONE

Designed by:
Japan International Cooperation
Agency (JICA)
JICA Study Team:
Joint Venture of
Pacific Consultants International and
Yamasa Sekkei Inc.
Subcontracted Local Consultant:


consolidated consultants
ENGINEERING & ARCHITECTURE
Tel: 4822777 - Fax: 4822800 - 488888 - 20904

Date: June 2000


ELEVATIONS

Drawing Title:


Scale: 1/50 Drawing No.: LOP.A-006

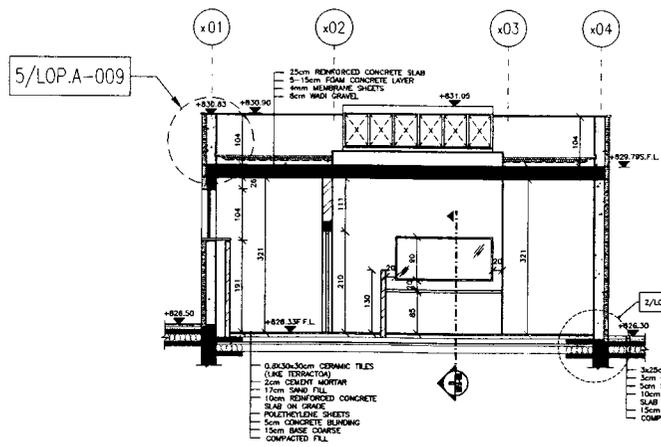

SECTION (A-A)

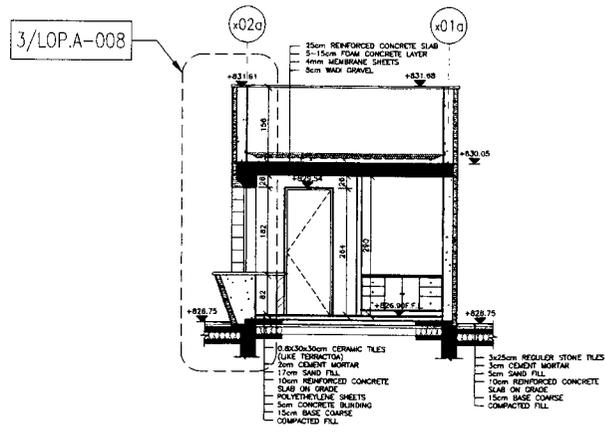

SECTION (C-C)

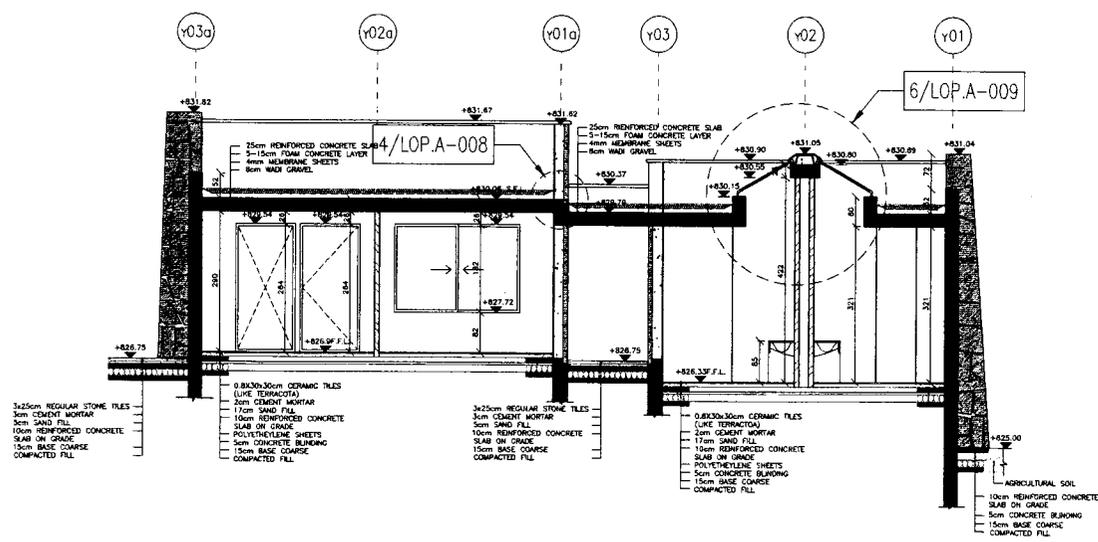

SECTION (B-B)

Project:
Tourism Sector Development Project
in the Hashemite Kingdom of Jordan

Executing Agency
The Ministry of Tourism and Antiquities
The Ministry of Planning

SUB-PROJECT:
Karak Tourism Development Project
Lower Observation Point

Note:
This detailed design has been executed by a team of consultants as shown below in accordance with the agreement between Japan International Cooperation Agency (JICA) and JICA Study Team.
The copyright of this drawing rests with JICA.

Designed by:
Japan International Cooperation Agency (JICA)
JICA Study Team:
Joint Venture of
Pacific Consultants International and
Yamashita Sekkei Inc.
Subcontracted Local Consultant:

consolidated consultants
CONSOLIDATED CONSULTANTS
Tel: 4812377 - Fax: 4812380 - 10000 - 20000


| | | |
|-------|------|------|
| Date: | June | 2000 |
|-------|------|------|

SECTIONS


Drawing Title:

| | | |
|--------|--------------|-----------|
| Scale: | Drawing No.: | LOP.A-007 |
| 1/50 | | |


| MANHOLE SCHEDULE | | | | | | |
|------------------|-----------------|------------------|-------------------|-------------------|-----------------|-------|
| No. | COVER LEVEL (m) | INVERT LEVEL (m) | MANHOLE DEPTH (m) | MANHOLE SIZE (mm) | COVER SIZE (mm) | NOTES |
| MHT | 258.40 | 252.40 | 6.00 | 800x800 | 800 | |
| MHC | 258.00 | 252.00 | 7.00 | 800x800 | 800 | |
| MFD | 256.00 | 254.50 | 1.50 | 800 | 800 | |
| MHA | 258.00 | 254.75 | 3.25 | 800 | 800 | |

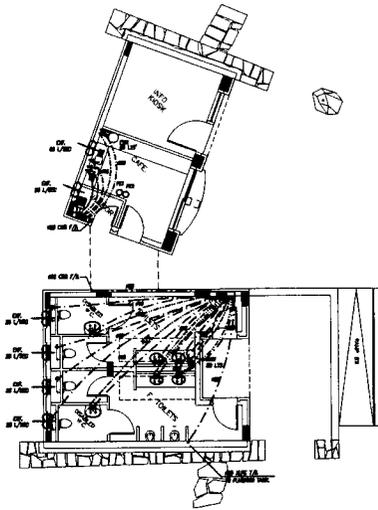


GROUND FLOOR PLAN WATER DISTRIBUTION LAYOUT
(1/200)

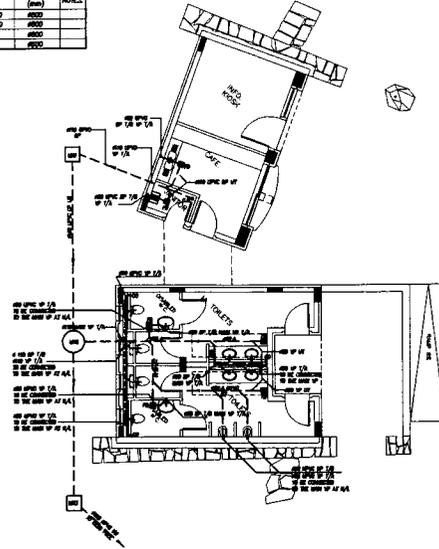

GROUND FLOOR PLAN DRAINAGE LAYOUT
(1/200)

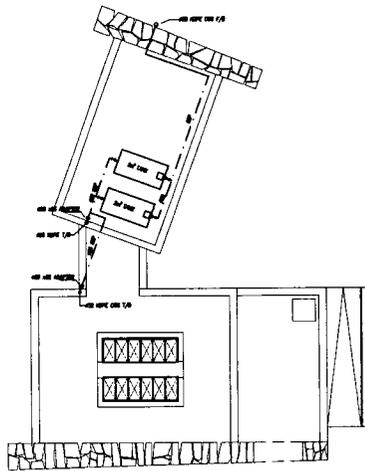

ROOF PLAN WATER DISTRIBUTION LAYOUT
(1/200)

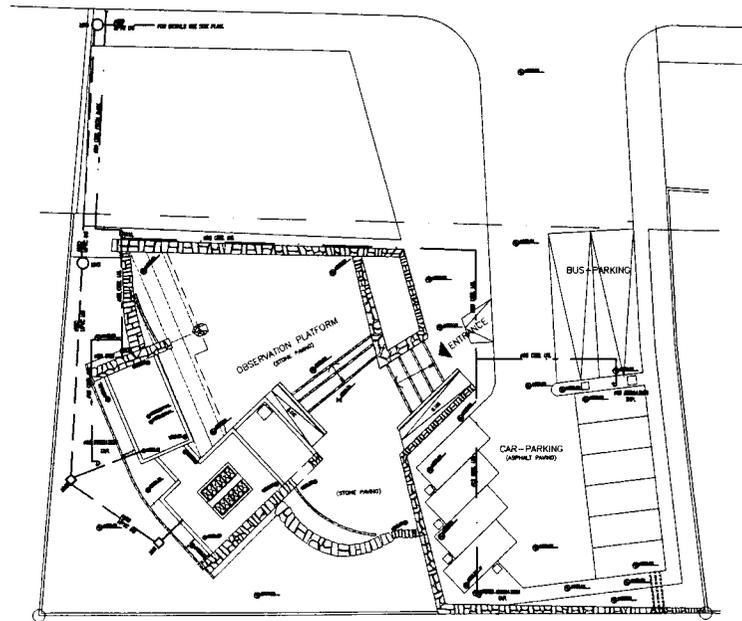

SITE PLAN MECHANICAL WORK
(1/200)

Project:
Tourism Sector Development Project
in the Hashemite Kingdom of Jordan

Executing Agency
The Ministry of Tourism and Antiquities
The Ministry of Planning

SUB-PROJECT:
Karak Tourism Development Project
Lower Observation Point

Note:
This detailed design has been executed by a team of consultants as shown below in accordance with the agreement between Japan International Cooperation Agency (JICA) and JICA Study Team.
The copyright of this drawing rests with JICA.

F21 FIRE EXTINGUISHER 8kg (20%)
F22 FIRE EXTINGUISHER 8kg (20%)
CP CONCRETE PIPE
WJ WATER AUTHORITY OF JORDAN

SYMBOLS:

- W STRONG
- FD FLOOR DRAIN
- CO CLEAN OUT
- DP DRAIN PIPE
- CD COLD WATER SUPPLY
- DP DRAIN PIPE
- HW HOT WATER SUPPLY

GENERAL NOTES:

- ALL DRAINAGE PIPES SHALL BE UPVC CLASS 18 BAR
- ALL UNDER FLE DOMESTIC WATER PIPES SHALL BE RUPC UNLESS COVER WISE SHOWN
- ALL MANHOLE COVERS SHALL BE METRIC DUTY
- EXTRACT FANS SHALL BE ACCOMPANIED WITH AUTOMATIC SHUTTER
- CONTRACTOR SHALL COMPLY WITH ALL REGULATIONS FOR MANHOLE PIPE CROSSING THE STREET, ETC.
- CONTRACTOR SHALL COORDINATE ALL HIS WORKS WITH WJ PRIOR TO INSTALLATION.

Designed by:
Japan International Cooperation Agency (JICA)
JICA Study Team:
Joint Ventures of
Pacific Consultants International and
Yamasei Sakkel Inc.
Subcontracted Local Consultant:

consolidated consultants
CONSULTANTS & ENGINEERS
Tel: 4412377 - Fax: 4412388 - AMMAN - JORDAN

Date: June 2000

Drawing Title: MECHANICAL WORKS

Scale: Drawing No: LOP.M-001

DISTRIBUTION PANEL BOARD

BUILDING : LOWER OBSERVATION LOCATION : W.C. PANEL NO. : DBB

VOLTAGE & FREQ. : 230V, 50Hz CABLE ENTRY : TOP & BOTTOM

| DESIGNATION OF LOAD | NO. | TRIP RATING | |
|---------------------|-----|-------------------------|------------|
| | | SIZE (mm ²) | RATING (A) |
| LIGHTING | 2.5 | 3 | 10A |
| H.DRAYER | 4 | 3 | 20A |
| H.DRAYER | 4 | 3 | 20A |
| W.HEATER | 4 | 3 | 20A |
| SPARE | | | 15A |
| SPARE | | | 8A |

TOTAL CONNECTED WATTS : 2800 → 50A/30mA ELCB

| | LIGHTING | HEAT | MISC. | TOTAL |
|------------------------|----------|------|-------|-------|
| TOTAL CONNECTED LOAD : | 3.58 | | | |
| TOTAL DEMAND LOAD : | 2.18 | | | |

DISTRIBUTION PANEL BOARD


BUILDING : LOWER OBSERVATION LOCATION : INFO ROOM PANEL NO. : DBA

VOLTAGE & FREQ. : 230V, 50Hz CABLE ENTRY : TOP & BOTTOM

| DESIGNATION OF LOAD | NO. | TRIP RATING | |
|---------------------|-----|-------------------------|------------|
| | | SIZE (mm ²) | RATING (A) |
| LIGHTING | 2.5 | 3 | 10 |
| S.OUTLET | 2.5 | 3 | 15 |
| S.OUTLET | 2.5 | 3 | 15 |
| HEATER | 4 | 3 | 20 |
| SPARE | | | 15 |

TOTAL CONNECTED WATTS : 1850 → 40A/30mA ELCB

| | LIGHTING | HEAT | MISC. | TOTAL |
|------------------------|----------|------|-------|-------|
| TOTAL CONNECTED LOAD : | 1.08 | | | |
| TOTAL DEMAND LOAD : | 0.25 | | | |

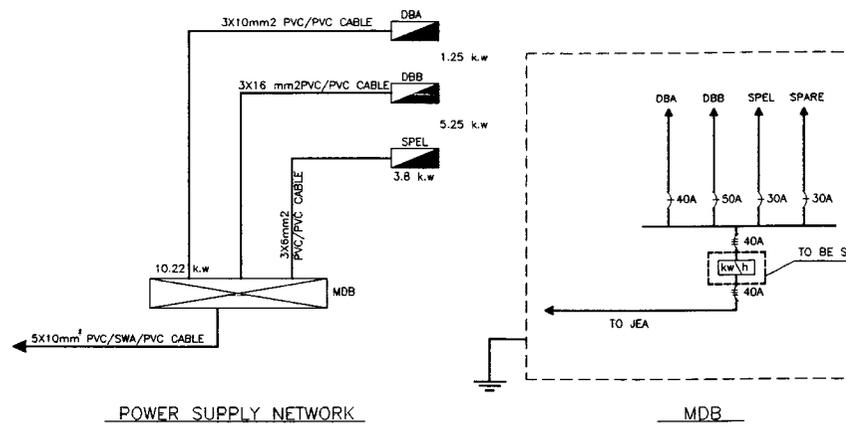

Project:
Tourism Sector Development Project
in the Hashemite Kingdom of Jordan



Executing Agency
The Ministry of Tourism and Antiquities
The Ministry of Planning

SUB-PROJECT:
Karak Tourism Development Project
Lower Observation Point

Note:
This detailed design has been executed by a team of consultants as shown below in accordance with the agreement between Japan International Cooperation Agency (JICA) and JICA Study Team.
The copyright of this drawing rests with JICA.

LEGEND

- WIRE OR CABLE IN CONDUIT UNDER FLOOR #25mm (OTHERWISE INDICATED).
- DIRECT BURIED CABLE
- ▽ TELEPHONE SOCKET OUTLET.
- POWER MANHOLE (40x40x40cm)

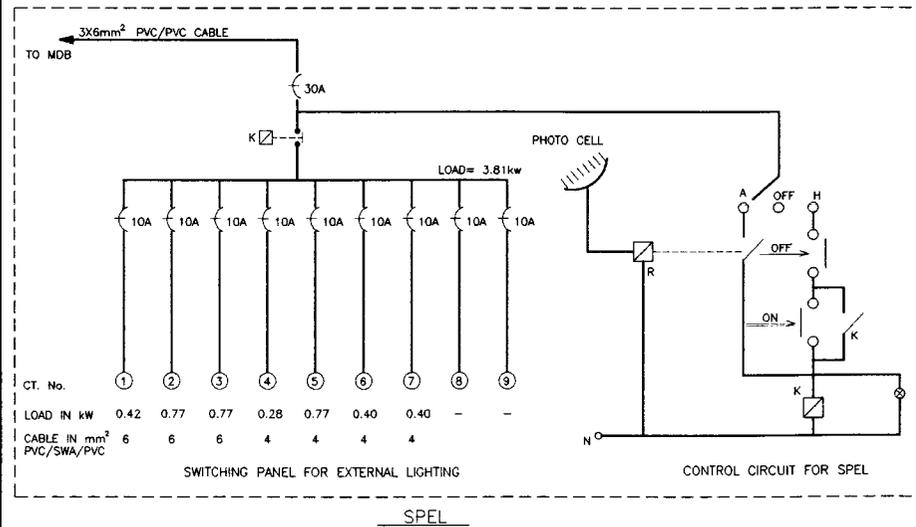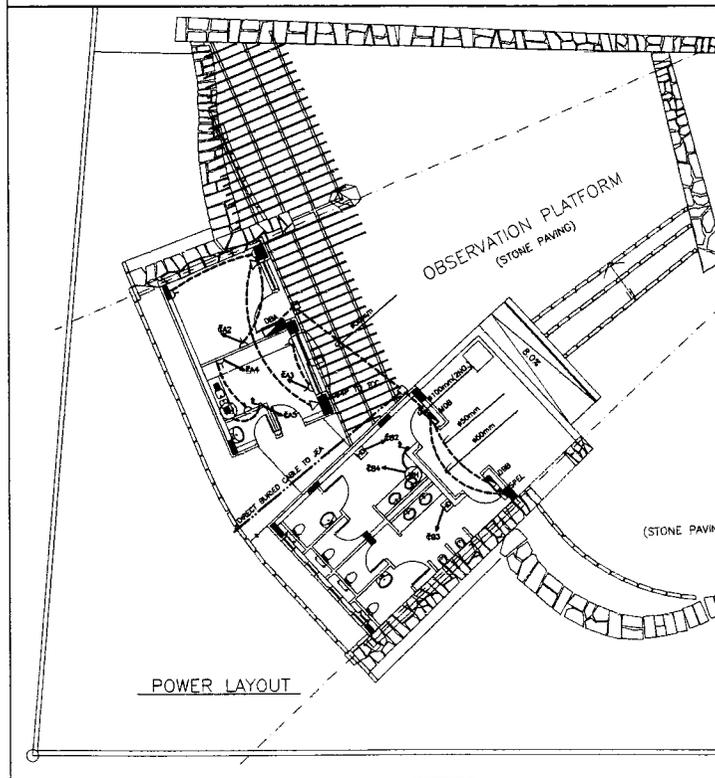


Designed by:
Japan International Cooperation Agency (JICA)
JICA Study Team:
Joint Venture of Pacific Consultants International and Yamasa Sekkei Inc.
Subcontracted Local Consultant:
consolidated consultants
JICA ENGINEERING & CONSULTANTS
P.O. BOX 1277 - FAC 91220 - AMMAN - JORDAN

Date: June 2000

POWER, TELEPHONE & ELECTRICAL PANELS

Drawing Title:

Scale: 1:1 Drawing No.: LOP.E-002

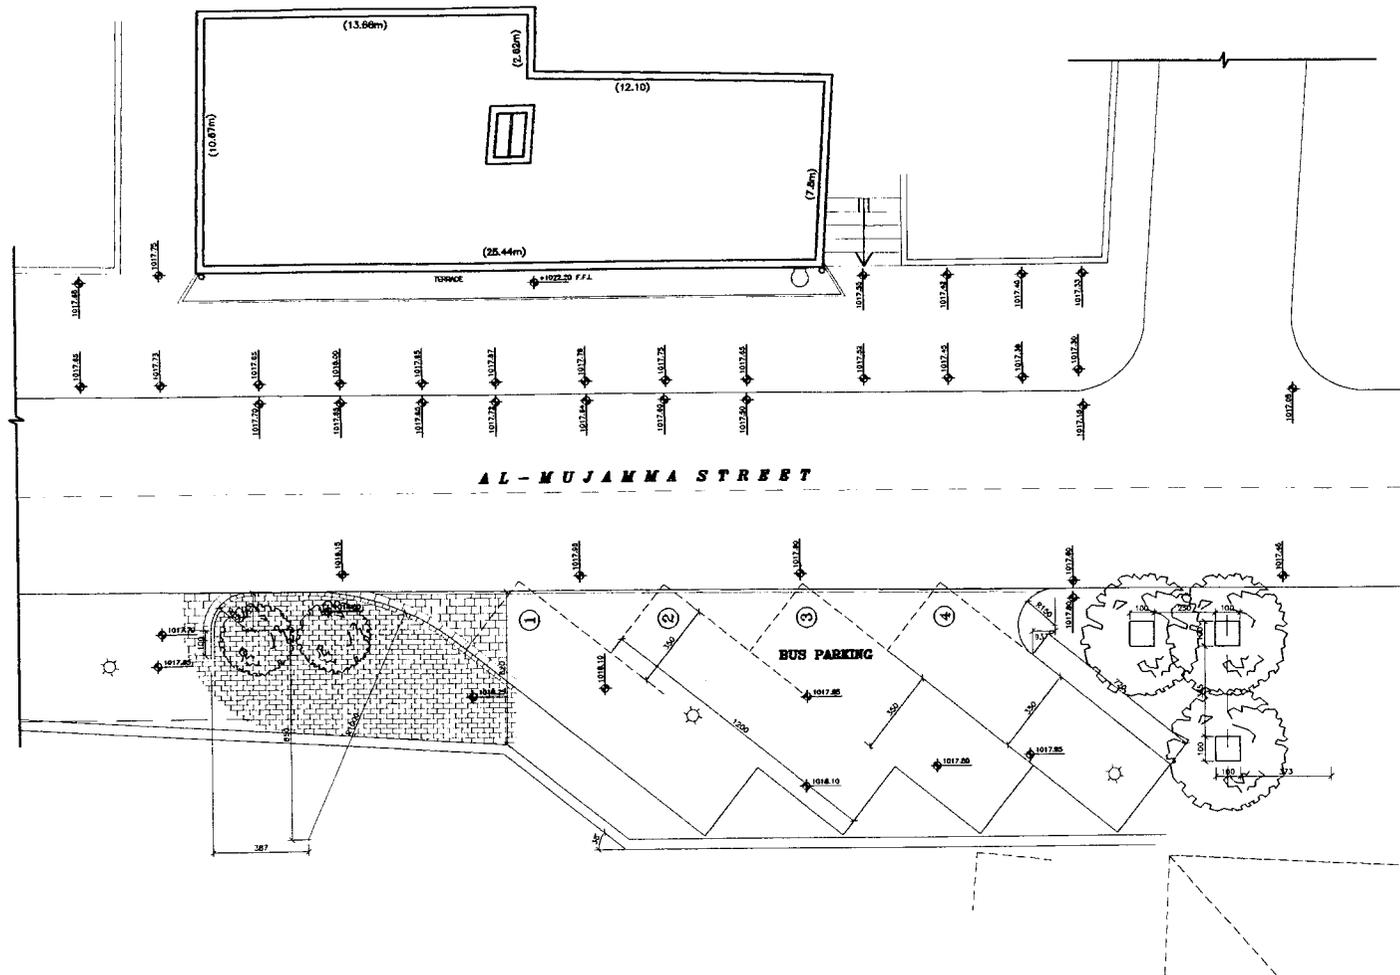


Project:
 Tourism Sector Development Project
 in the Hashemite Kingdom of Jordan

Executing Agency
 The Ministry of Tourism and Antiquities
 The Ministry of Planning

SUB-PROJECT:
 Karak Tourism Development Project
 Walkers Center

Note:
 This detailed design has been executed by
 a team of consultants as shown below in
 accordance with the agreement between
 Japan International Cooperation Agency
 (JICA) and JICA Study Team.
 The copyright of this drawing rests with
 JICA.

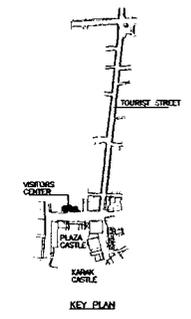


Designed by:
 Japan International Cooperation
 Agency (JICA)
 JICA Study Team:
 Joint Venture of
 Pacific Consultants International and
 Yamashita Sekihei Inc.
Subcontracted Local Consultant:

consolidated consultants
 CONSULTING & ARCHITECTS
 14, 16/177 - 1st FLOOR - AMMAN - JORDAN


Date: June 2000

SITE PLAN
 Drawing Title:


Scale: 1:100 Drawing No.: VC.A-001

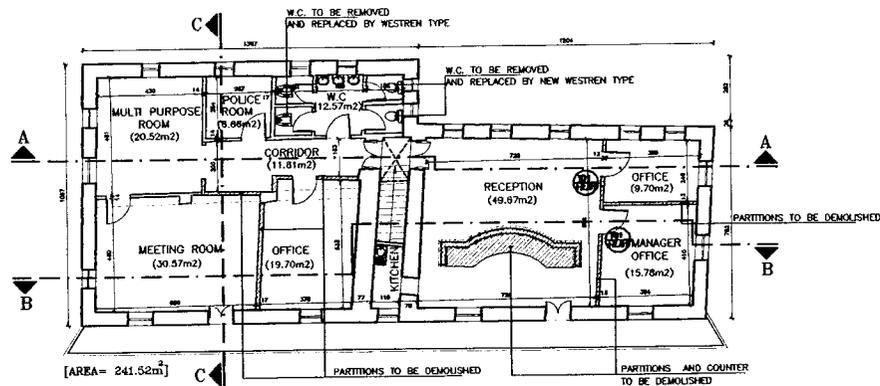


PLAN
1/100

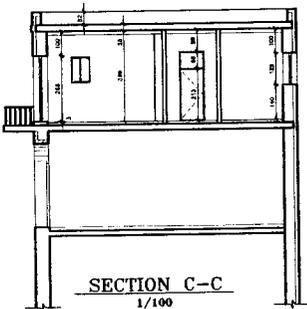


SECTION C-C
1/100

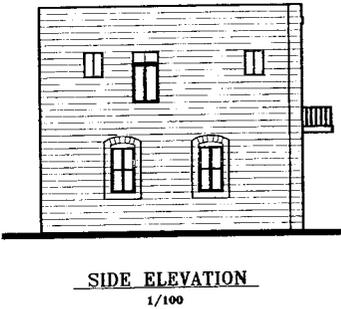


SIDE ELEVATION
1/100

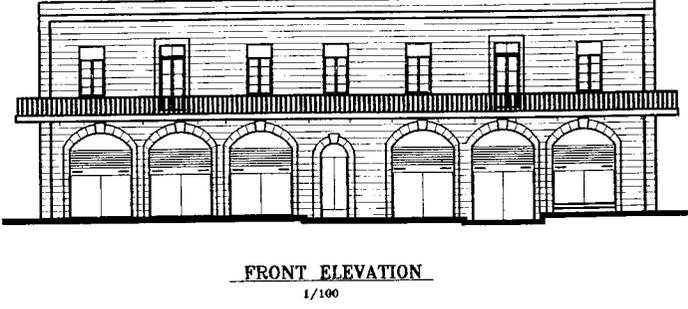

FRONT ELEVATION
1/100

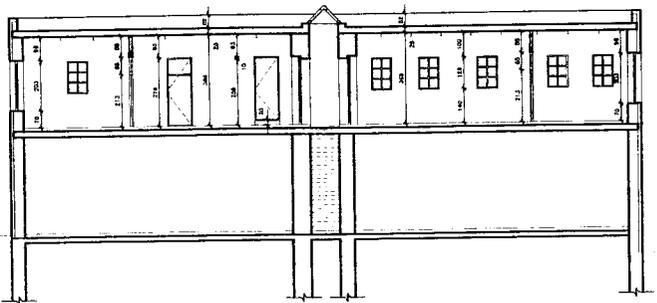

SECTION A-A
1/100

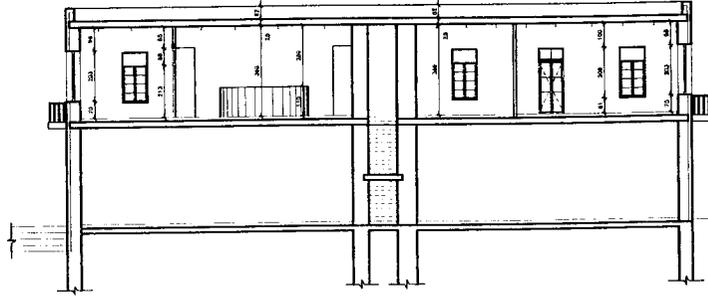

SECTION B-B
1/100

Project:
Tourism Sector Development Project
in the Hashemite Kingdom of Jordan

Executing Agency
The Ministry of Tourism and Antiquities
The Ministry of Planning

SUB-PROJECT:
Karak Tourism Development Project
Wulkoff Center

Note:
This detailed design has been executed by a team of consultants as shown below in accordance with the agreement between Japan International Cooperation Agency (JICA) and JICA Study Team.
The copyright of this drawing rests with JICA.

KEY PLAN


Designed by:
Japan International Cooperation Agency (JICA)
JICA Study Team:
Joint Venture of Pacific Consultants International and Yamashita Sekkei Inc.
Subcontracted Local Consultant:




Date: June 2000

EXISTING PLAN, ELEVATIONS AND SECTIONS
Drawing Title


Scale: 1:100
Drawing No.: VC.A-002

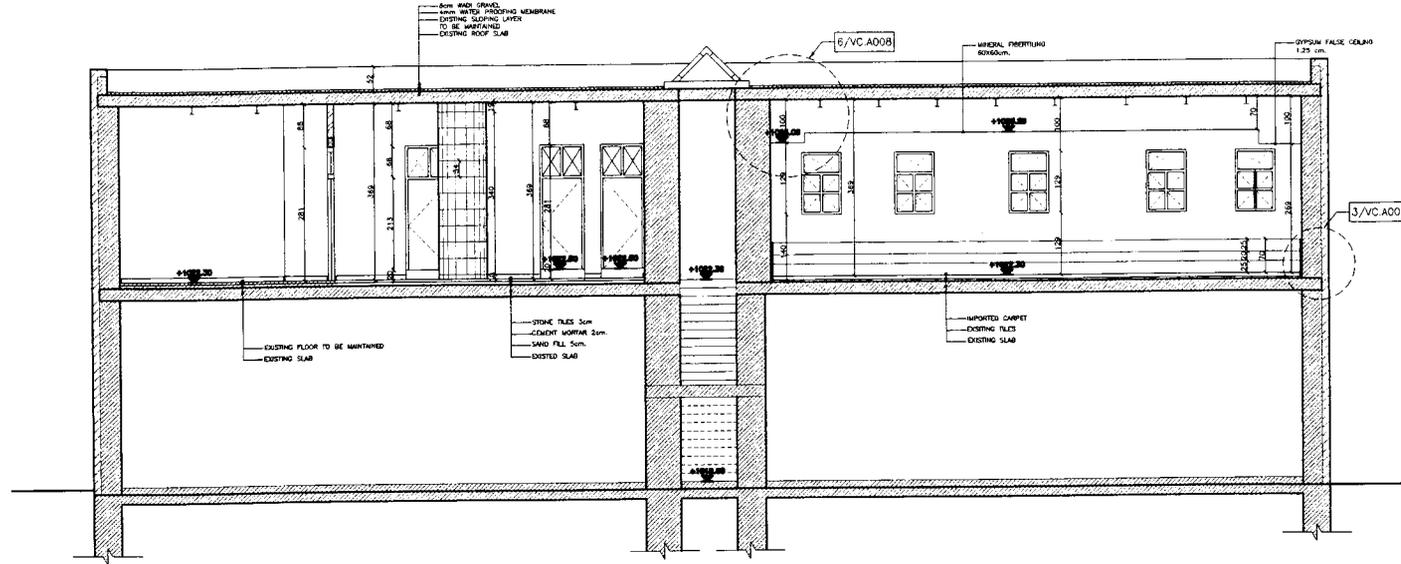

SECTION (A-A)

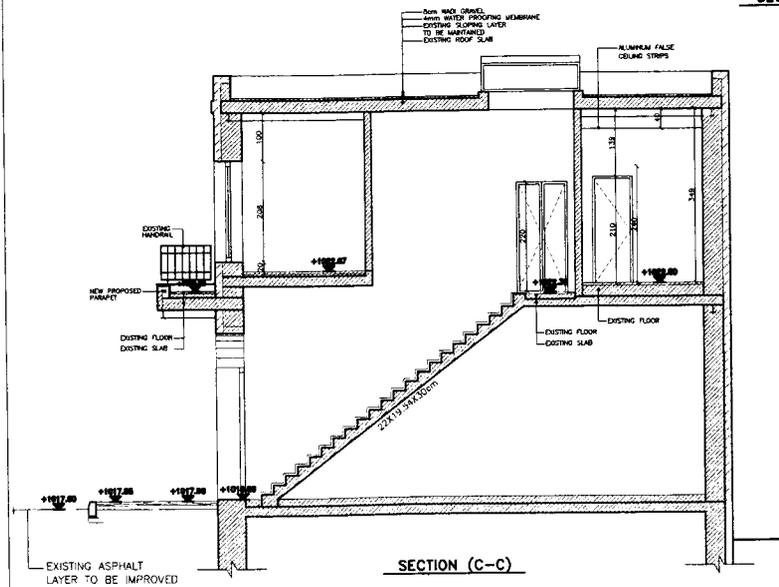

SECTION (C-C)

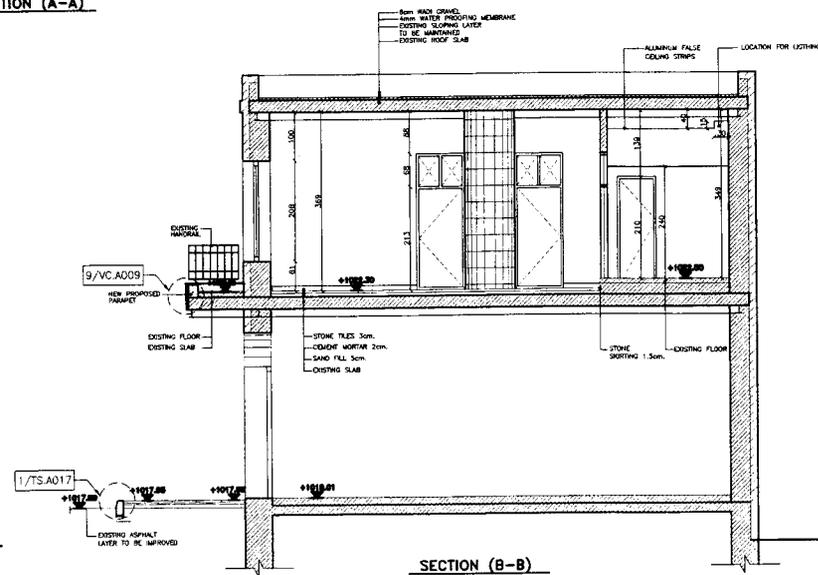

SECTION (B-B)

Project:
Tourism Sector Development Project
in the Hashemite Kingdom of Jordan

Executing Agency:
The Ministry of Tourism and Antiquities
The Ministry of Planning

SUB-PROJECT:
Karak Tourism Development Project
Visitors Center

Note:
This detailed design has been executed by a team of consultants as shown below in accordance with the agreement between Japan International Cooperation Agency (JICA) and JICA Study Team. The copyright of this drawing rests with JICA.


Designed by:
Japan International Cooperation Agency (JICA)
JICA Study Team:
Joint Venture of Pacific Consultants International and Yamashita Sekkei Inc.
Subcontracted Local Consultant:

consolidated consultants
CONSULTING & CONTRACTING
Tel: 4812377 - Fax: 4812380 - AMMAN - JORDAN


Date: June 2000

INTERNAL ELEVATIONS (SECTIONS)
Drawing Title:


Scale: 1:50
Drawing No.: VC.A-004

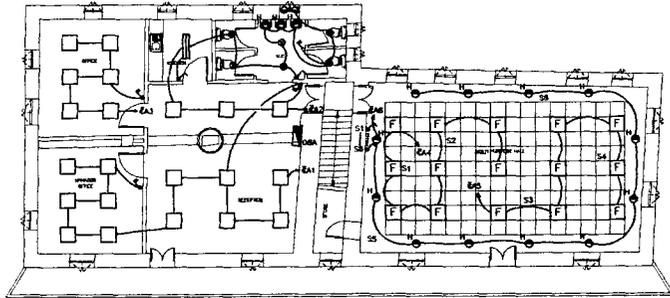


LIGHTING LAYOUT

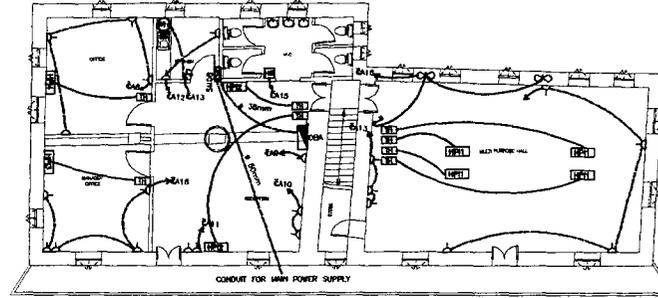


POWER LAYOUT

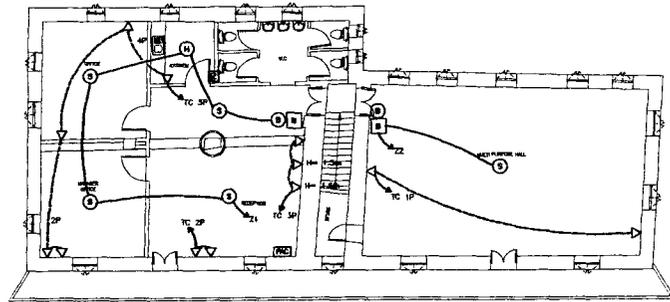


TELEPHONE & FIRE ALARM SYSTEMS

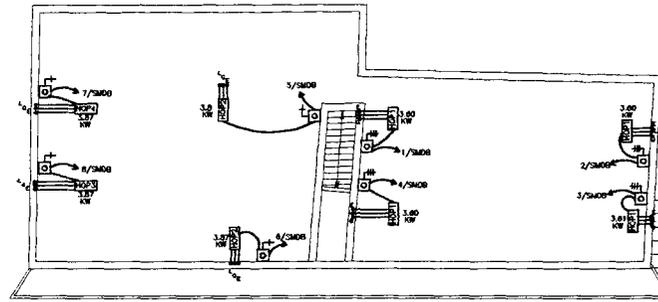


ROOF POWER

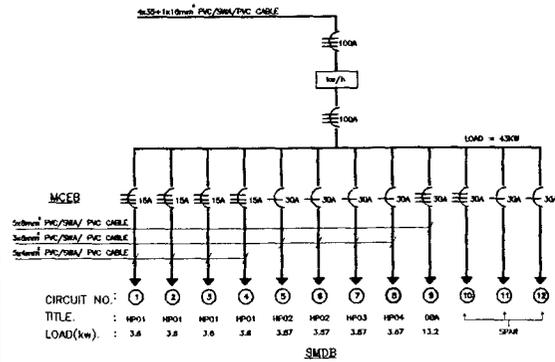

TELEPHONE RISER DIAGRAM

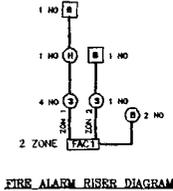

FIRE ALARM RISER DIAGRAM

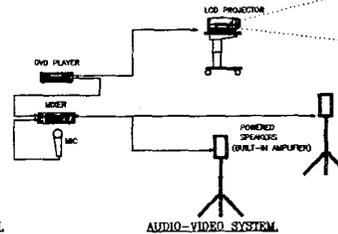

DISTRIBUTION PANEL BOARD

| NO. | DESCRIPTION OF LOAD | AMPS | WATTS | NO. | DESCRIPTION OF LOAD | AMPS | WATTS |
|-----|---------------------|------|-------|-----|---------------------|------|-------|
| 1 | LIGHTING | 2.8 | 2.8 | 1 | LIGHTING | 2.8 | 2.8 |
| 2 | LIGHTING | 2.8 | 2.8 | 2 | LIGHTING | 2.8 | 2.8 |
| 3 | LIGHTING | 2.8 | 2.8 | 3 | LIGHTING | 2.8 | 2.8 |
| 4 | WIRE | 2.8 | 2.8 | 4 | LIGHTING | 2.8 | 2.8 |
| 5 | ROCKET OUTLET | 2.8 | 2.8 | 5 | ROCKET OUTLET | 2.8 | 2.8 |
| 6 | ROCKET OUTLET | 2.8 | 2.8 | 6 | ROCKET OUTLET | 2.8 | 2.8 |
| 7 | ROCKET OUTLET | 2.8 | 2.8 | 7 | ROCKET OUTLET | 2.8 | 2.8 |
| 8 | WATER HEATER | 4 | 11.2 | 8 | ROCKET OUTLET | 2.8 | 2.8 |
| 9 | HAND DRYER | 4 | 11.2 | 9 | ROCKET OUTLET | 2.8 | 2.8 |
| 10 | ROCKET OUTLET | 2.8 | 2.8 | 10 | ROCKET OUTLET | 2.8 | 2.8 |
| 11 | ROCKET OUTLET | 2.8 | 2.8 | 11 | ROCKET OUTLET | 2.8 | 2.8 |
| 12 | ROCKET OUTLET | 2.8 | 2.8 | 12 | ROCKET OUTLET | 2.8 | 2.8 |

Project:
Tourism Sector Development Project
in the Hashemite Kingdom of Jordan

Executing Agency:
The Ministry of Tourism and Antiquities
The Ministry of Planning

SUB-PROJECT:
Karak Tourism Development Project
Walkers Center

Notes:
This detailed design has been executed by a team of consultants on whose behalf we are responsible with the agreement between Japan International Cooperation Agency (JICA) and JICA Study Team.
The copyright of this drawing rests with JICA.

- LEGEND AND NOTES:**
- 200W FLUORESCENT LIGHTING FIXTURE WITH PRAGMATIC OUTLET(F2)
 - 4X15w SURFACE MOUNTED FLUORESCENT WITH DOWNLIGHT(F1)
 - DITTO BUT RECESSED IN FALSE CEILING(F3)
 - 80w RECESSED SPOT LIGHT(F1)
 - 12v, 50w HALOGEN SPOT LIGHT WITH 230/12v TRANSFORMER(F2)
 - RA11 TELEPHONE OUTLET
 - KONZAROH SMOKE DETECTOR
 - BREAK GLASS CALL POINT
 - (F) ALARIN BELL
 - TELEPHONE CONNECTION BOX
 - 13A SOCKET OUTLET MOUNTED AT 450mm F.F.L
 - HAND DRYER
 - EXTRACT FAN
 - THERMOSTAT
 - (1) PHASE, EPS ISOLATOR
 - DITTO BUT (3) PHASE
 - RATE OF RISE HEAT DEFLECTOR
 - FIRE ALARM PANEL
 - 20A DOUBLE POLE SWITCH WITH FUSED LAMP
 - WATER HEATER
 - UNDER FLEES PVC COULST
 - ABOVE FALSE CEILING OR IN EXISTING SLAB PVC CONDUIT
 - 20mm PVC CONDUITS TO BE USED FOR LEADING CIRCUITS, FIRE ALARM, TELEPHONE, EXTRACT FANS AND THERMOSTAT.
 - 25mm PVC COULST TO BE USED FOR POWER SOCKET OUTLET AND HAND DRYERS.
 - 30mm PVC COULST TO BE USED FOR A/C SPLIT UNIT.

Designed by:
Japan International Cooperation Agency (JICA)
JICA Study Team:
Joint Venture of Pacific Consultants International and Yamomoto Seisaku Inc.

Subcontracted Local Consultant:

consolidated consultants
101, AL-SAYED ST. - JORDAN
TEL: 962-677-46000 - FAX: 962-677-46000

Date: June 2000

VISITOR CENTER
ELECTRICAL WORKS

Drawing No. VC.E-001

Scale: 1/100

Project
Tourism Sector Development Project
in the Hashemite Kingdom of Jordan

Executing Agency
The Ministry of Tourism and Antiquities
The Ministry of Planning

SUB-PROJECT:
Karak Tourism Development Project
Walkers Center

Note:
This detailed design has been executed by a team of consultants as shown below in accordance with the agreement between Japan International Cooperation Agency (JICA) and JICA Study Team.
The copyright of this drawing rests with JICA.

- NOTE:**
- 1- ALL DIMENSIONS ARE IN MM.
 - 2- CONTRACTOR SHALL COORDINATE ALL CEILING DIFFUSERS WITH REFLECTED CEILING PLAYS.
 - 3- CONTRACTOR SHALL CALCULATE SUPPLY AND EXTRACT FAN STATIC PRESSURE UPON FINAL SELECTION OF EQUIPMENT. PRESSURE LOSS SHALL INCLUDE ALL AIR INLETS AND OUTLETS, DAMPERS, FLEXIBLE DUCT WORK, FILTERS AND COILS.
 - 4- CONTRACTOR SHALL REFER TO DRAWING IN ORDER TO VERIFY ALL REQUIRED HOPE CRITERIA (W/C) FOR EACH SPACE.
 - 5- PREVAILING WIND DIRECTION SHALL BE CONSIDERED WHILE LOCATING FRESH AIR INTAKE TO PREVENT ANY EXHAUST INTRUSION INTO FRESH AIR INTAKE.
 - 6- ALL A/C COMPONENTS SHALL BE SELECTED UPON TOOTH OUTSIDE TEMPERATURE.

- LEGEND:**
- SD : SUPPLY CEILING DIFFUSER
 - RCO : RETURN CEILING GRILLE
 - DF : EXTRACT FAN
 - FA : FRESH AIR
 - HP : SPLIT HEAT PUMP INDOOR UNIT
 - HPO : SPLIT HEAT PUMP OUTDOOR UNIT
 - H/L : HIGH LEVEL
 - L/A : TO ABOVE
 - F/B : FROM BELOW
 - 0 : TO BELOW
 - S/L : SUCTION LINE
 - L : LIQUID LINE
 - E : ELECTRICAL CONNECTION
 - F.E2 : FINE EXTRACTOR (kg (bar))
 - F.E1 : FINE EXTRACTOR (kg (G22))
 - F.O : FLOOR DRAIN
 - DF : EXHAUST FAN
 - HC : HOOK PLACE CEILING
 - CT : ROOM THERMOSTAT

Designed by:
Japan International Cooperation Agency (JICA)
JICA Study Team:
Joint Venture of Pacific Consultants International and Yamanaka Seimei Inc.
Subcontracted Local Consultant:

consultants
12 441277 - fax 441281 - 0000 - 0000

Date: June 2000

MECHANICAL WORKS

Drawing Title

Scale: 1/100
Drawing No.: VC.W-001


18/12/1999

| HEAT PUMP SCHEDULE | | | | | | | | | | | | | |
|--------------------|--------------------|--------------|------|----------|------------------------|---------------|---------|-------------------|---------|------|---|--|-------------------------|
| No. | SERVED AREA | COOLING COIL | | | HEATING CAPACITY kW | SUPPLY FAN | | EST. COMP. COEFF. | MCC No. | TYPE | | | |
| | | COIL NO. | TYPE | CAPACITY | | EST. TOTAL kW | EST. KW | | | | | | |
| HP1 | MULTI PURPOSE HALL | 29.2 | 19.2 | 12.8 | 6.862 | 11.158 | 8.448 | 5.0 | 0.075 | 3.58 | N | | DUCTED |
| HP2 | RECEPTION | 23.5 | 15.3 | 10.9 | 12.1 | 6.302 | 7.508 | - | - | 3.87 | H | | DECORATIVE WALL MOUNTED |
| HP3 | MANAGER OFFICE | 24.1 | 15.8 | 14.0 | 10.8 | 8.348 | 8.100 | - | - | 3.87 | H | | DECORATIVE WALL MOUNTED |
| HP4 | OFFICE | 23.8 | 15.5 | 12.1 | 8.461 | 7.812 | 7.123 | - | - | 3.87 | N | | DECORATIVE WALL MOUNTED |


| FANS SCHEDULE | | | | | | | | |
|---------------|----------|--------------------|-------------------|-------------------------|------------|------------|-----------|-------------------------------------|
| FAN NO. | LOCATION | SERVED AREA | CAPACITY L/SEC | ESTM TOTAL SP/MinH2O | ESTM kW | M.C.C. NO. | | REMARKS |
| | | | | | | NORMAL | EMERGENCY | |
| EXP.1 | WALL | TOILETS | 100 | - | 0 | H | | WALL MOUNTED WITH AUTOMATIC SHUTTER |
| EXP.2 | WALL | MULTI PURPOSE HALL | 300 | - | 0.040 | N | | WALL MOUNTED WITH AUTOMATIC SHUTTER |

| DIFFUSER SCHEDULE | | | | | | | |
|-------------------|-------------------|--------------------|--------------------|------------|----|-----|----------------------------|
| DIFFUSER NO. | AIR FLOW L/SEC | SERVED AREA | HOOK SIZE MMxMM | THROW M | NO | QTY | TYPE |
| SCD-1 | 237 | MULTI PURPOSE HALL | 300x300 | 5.0 | 23 | 8 | FOUR WAY -CEILING DIFFUSER |

| RETURN GRILLE SCHEDULE | | | |
|------------------------|---------------|-----|--------------|
| GRILLE No. | SIZE mmxmm | QTY | TYPE |
| RCO1 | 400x400 | 4 | CEILING TYPE |

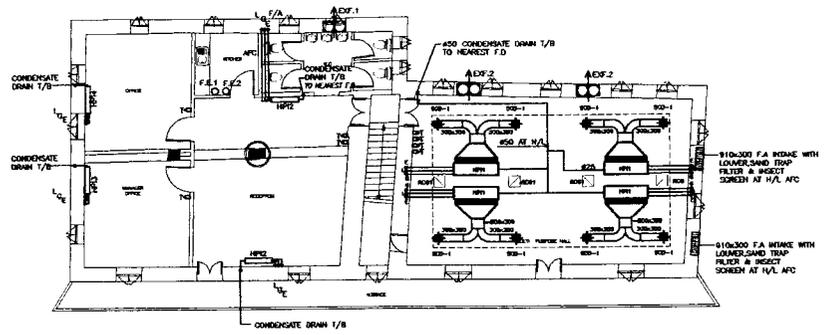

FIRST FLOOR PLAN HVAC LAYOUT
(1:100)

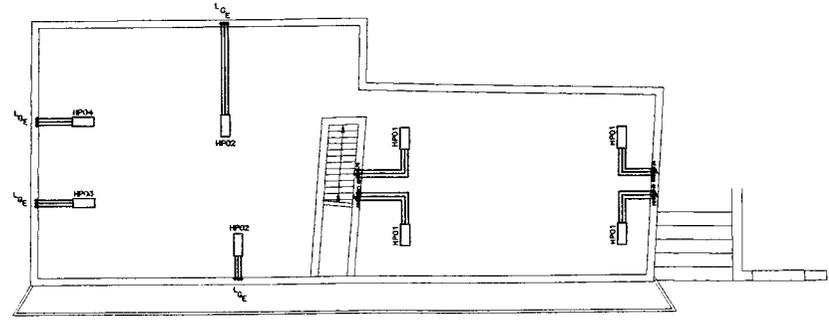

ROOF PLAN HVAC LAYOUT
(1:100)