



The Project for Rehabilitation of Baluchaung No.2 Hydro Power Plant in the Union of Myanmar			
DWN		SCALE	TITLE
CHKD			Single Line Diagram of Kalaw Substation
APPD		DATE	
NIPPON KOEI CO., LTD. TOKYO ELECTRIC POWER CO., LTD.		1st October, 2001	DWG No. BAC-TL-0001

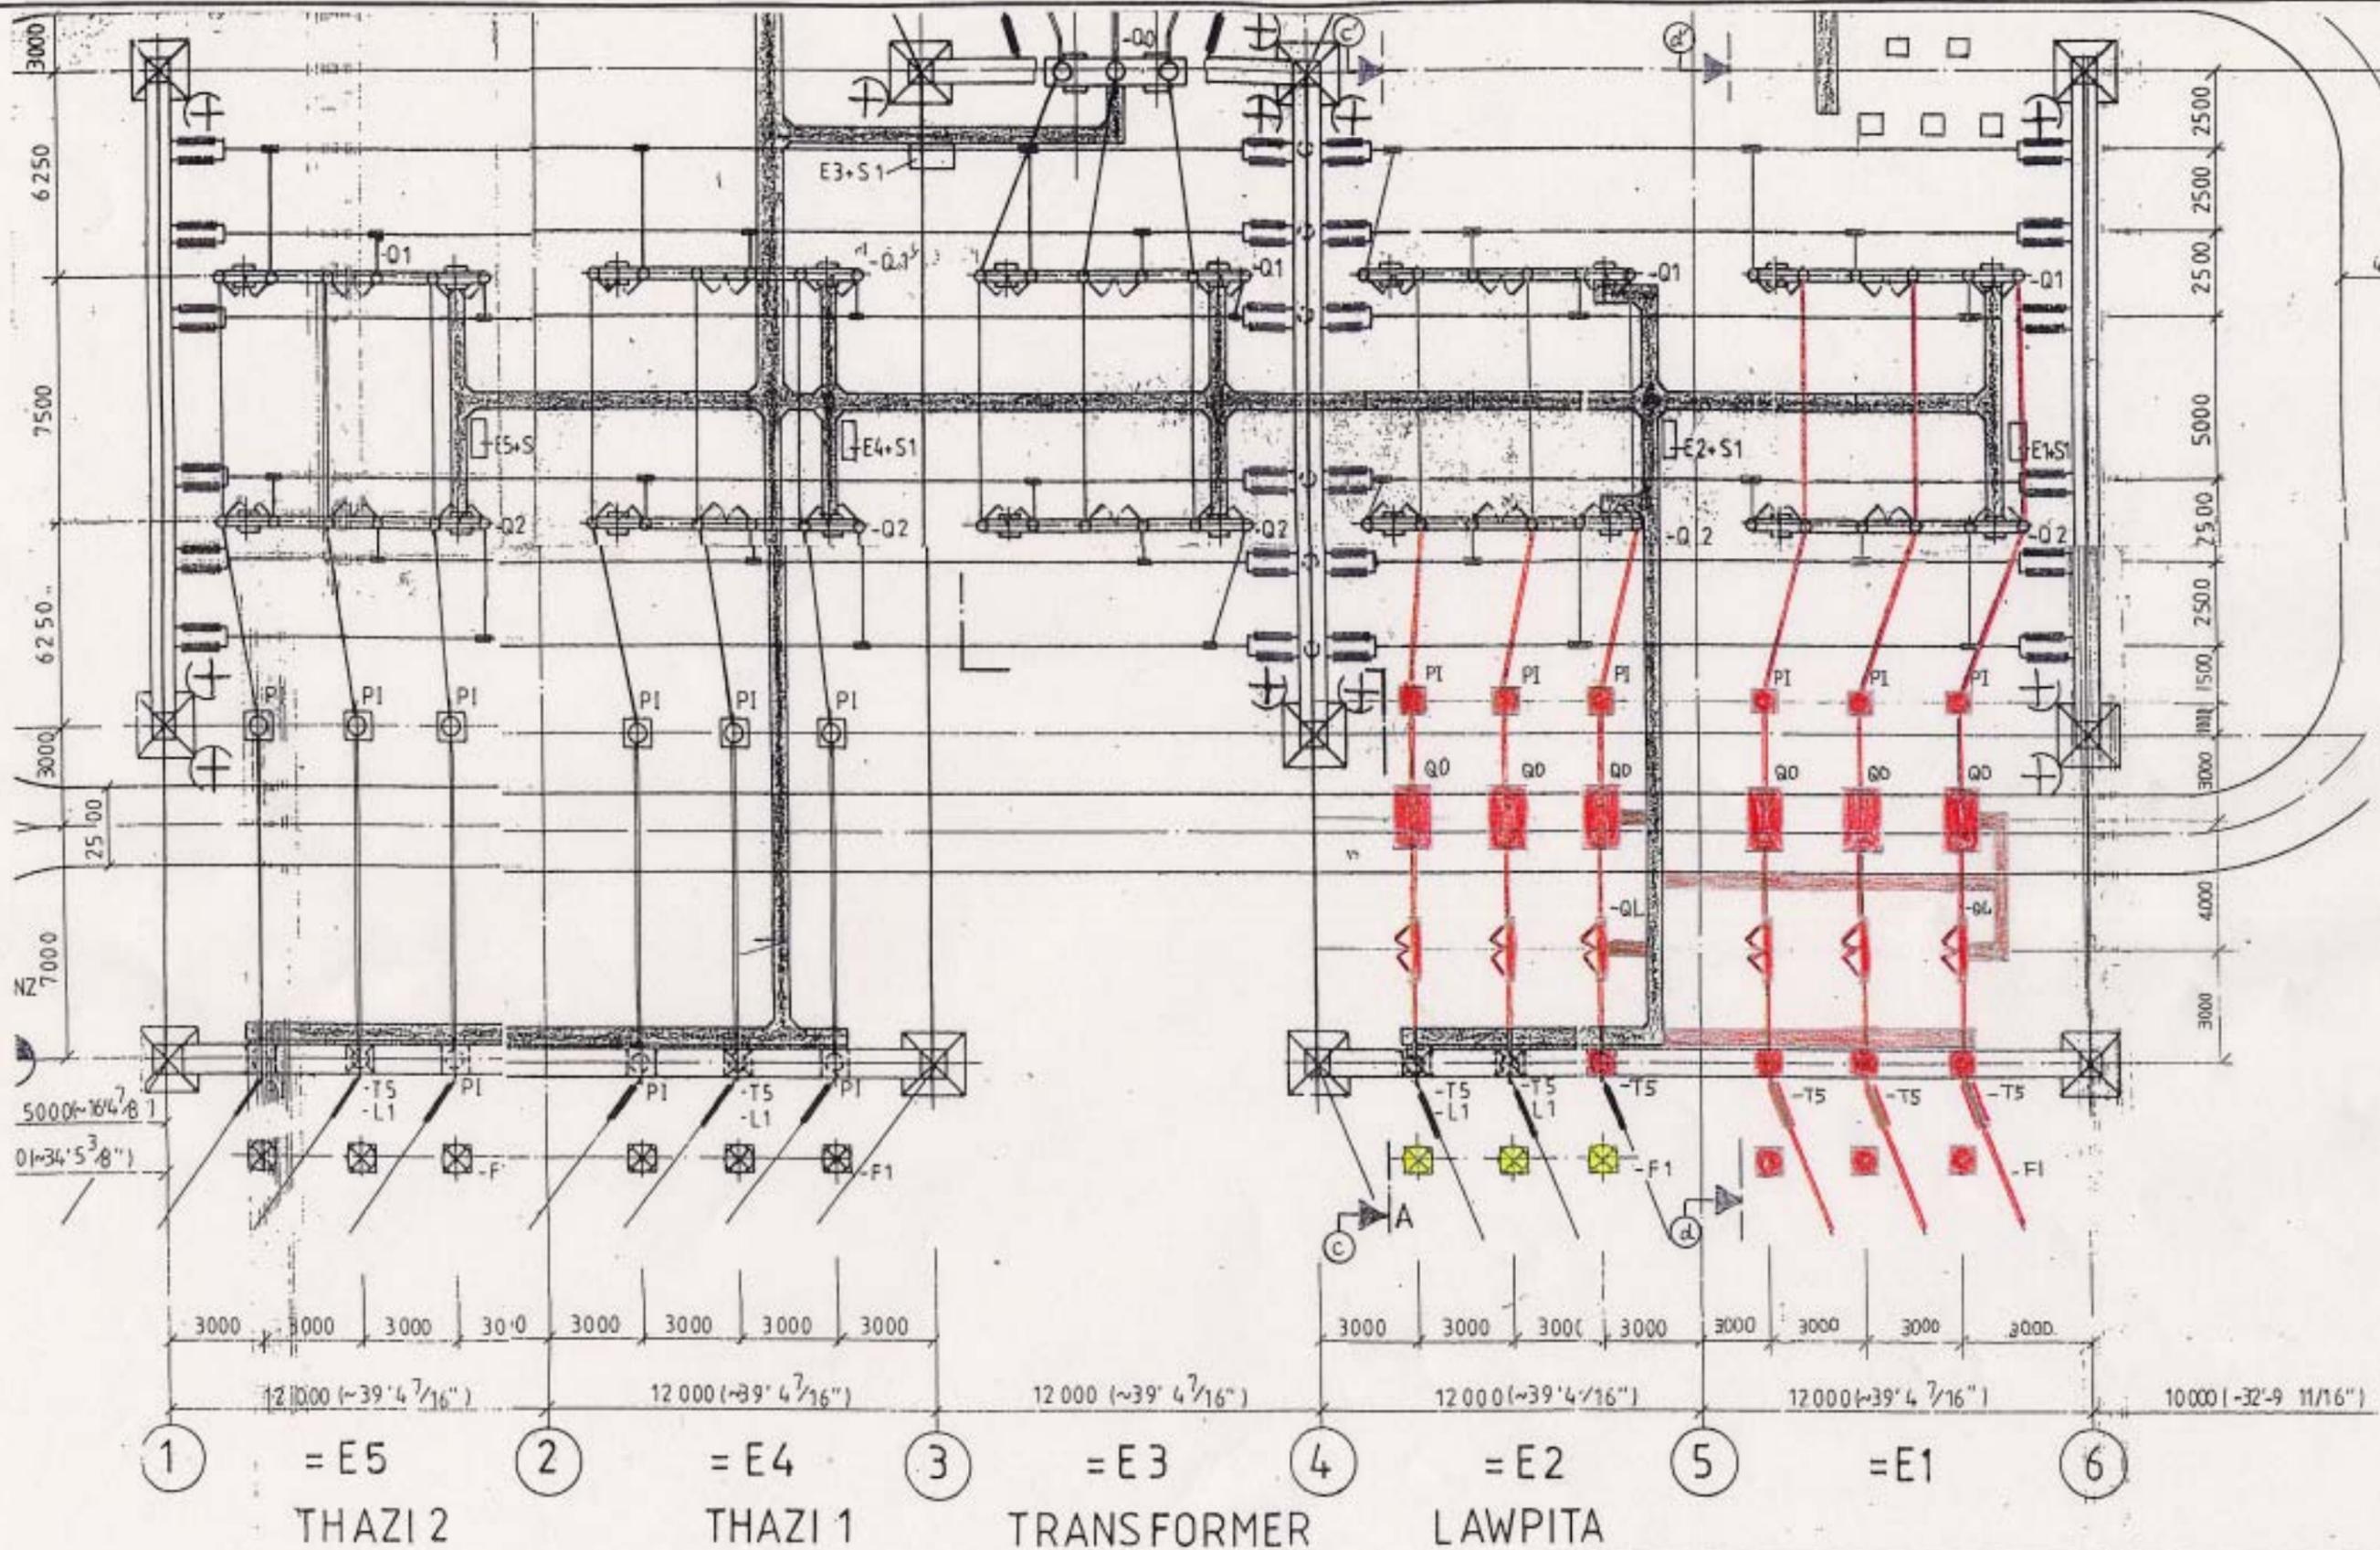


The Project for Rehabilitation of Baluchaung No.2 Hydro Power Plant in the Union of Myanmar			
DWN	<i>Mukai</i>	SCALE	TITLE Ground Plan of Kalaw Substation
CHKD	<i>Nomata</i>	DATE	
APPD	<i>Nomata</i>	1st October, 2001	DWG No. BAC-TL-0002
NIPPON KOEI CO., LTD. TOKYO ELECTRIC POWER CO., LTD.			

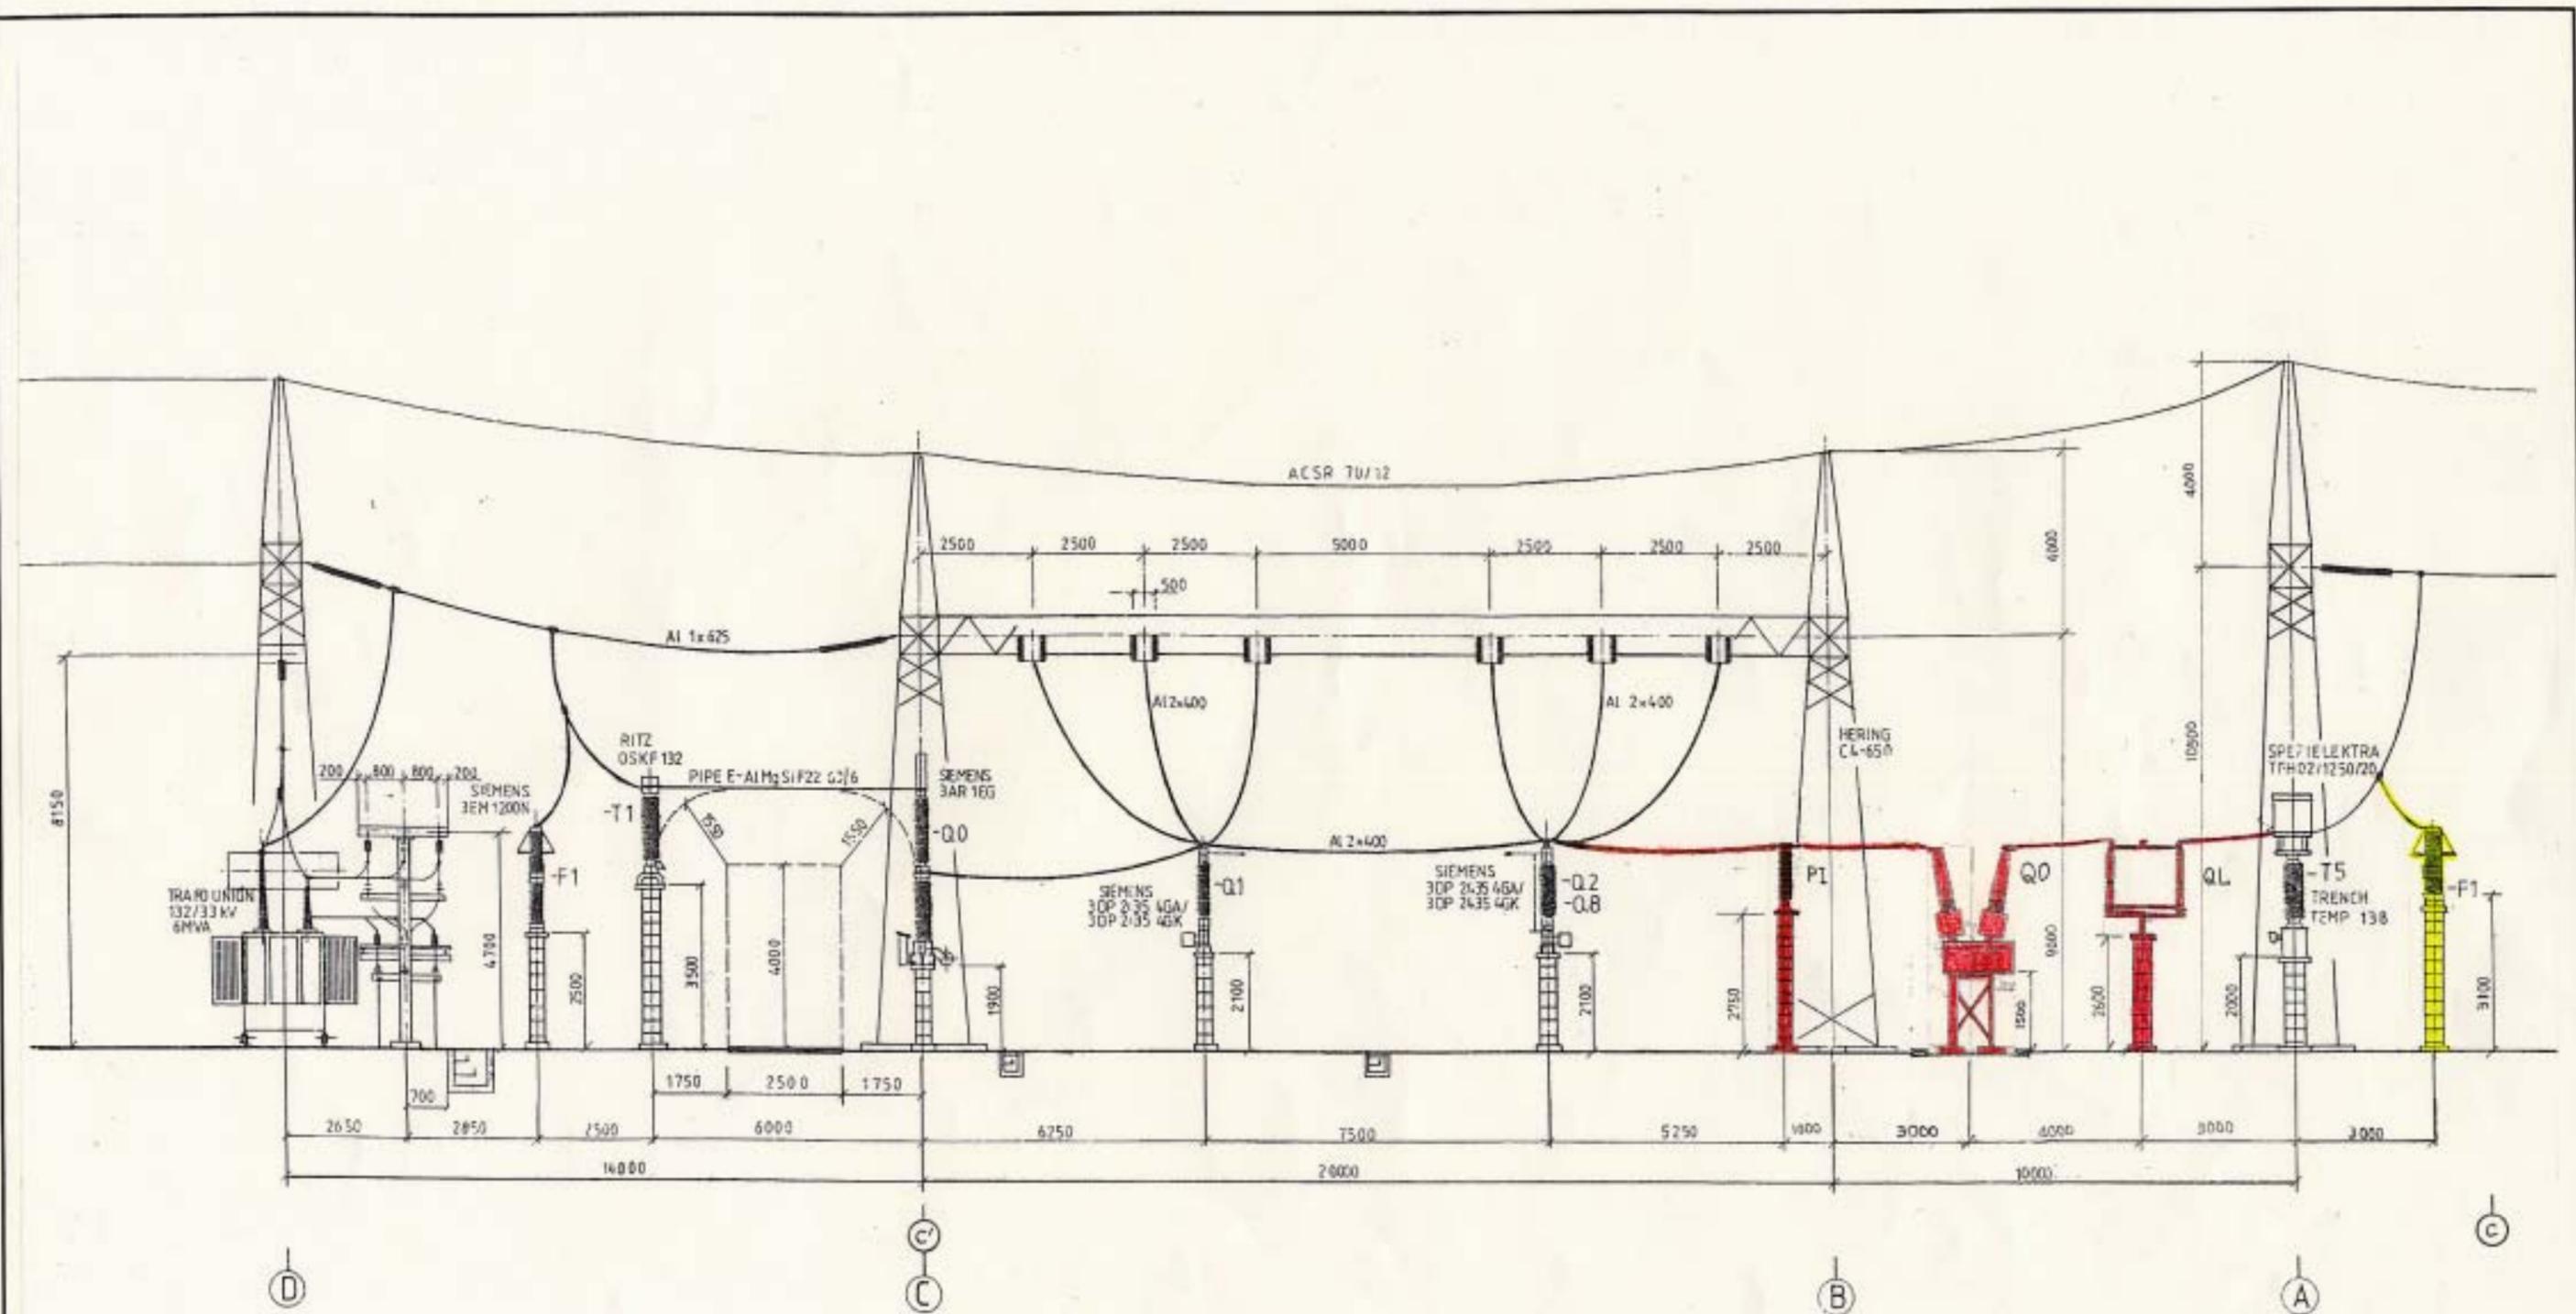


The Project for Rehabilitation of Baluchaung No.2 Hydro Power Plant in the Union of Myanmar


DWN	<i>Murkin</i>	SCALE	TITLE
CHKD	<i>N. Matsu</i>		Elevation of Lawpita 1L of Kalaw Substation
APPD	<i>N. Matsu</i>	DATE	
NIPPON KOEI CO., LTD. TOKYO ELECTRIC POWER CO., LTD.		1st October, 2001	DWG No. BAC-TL-0003

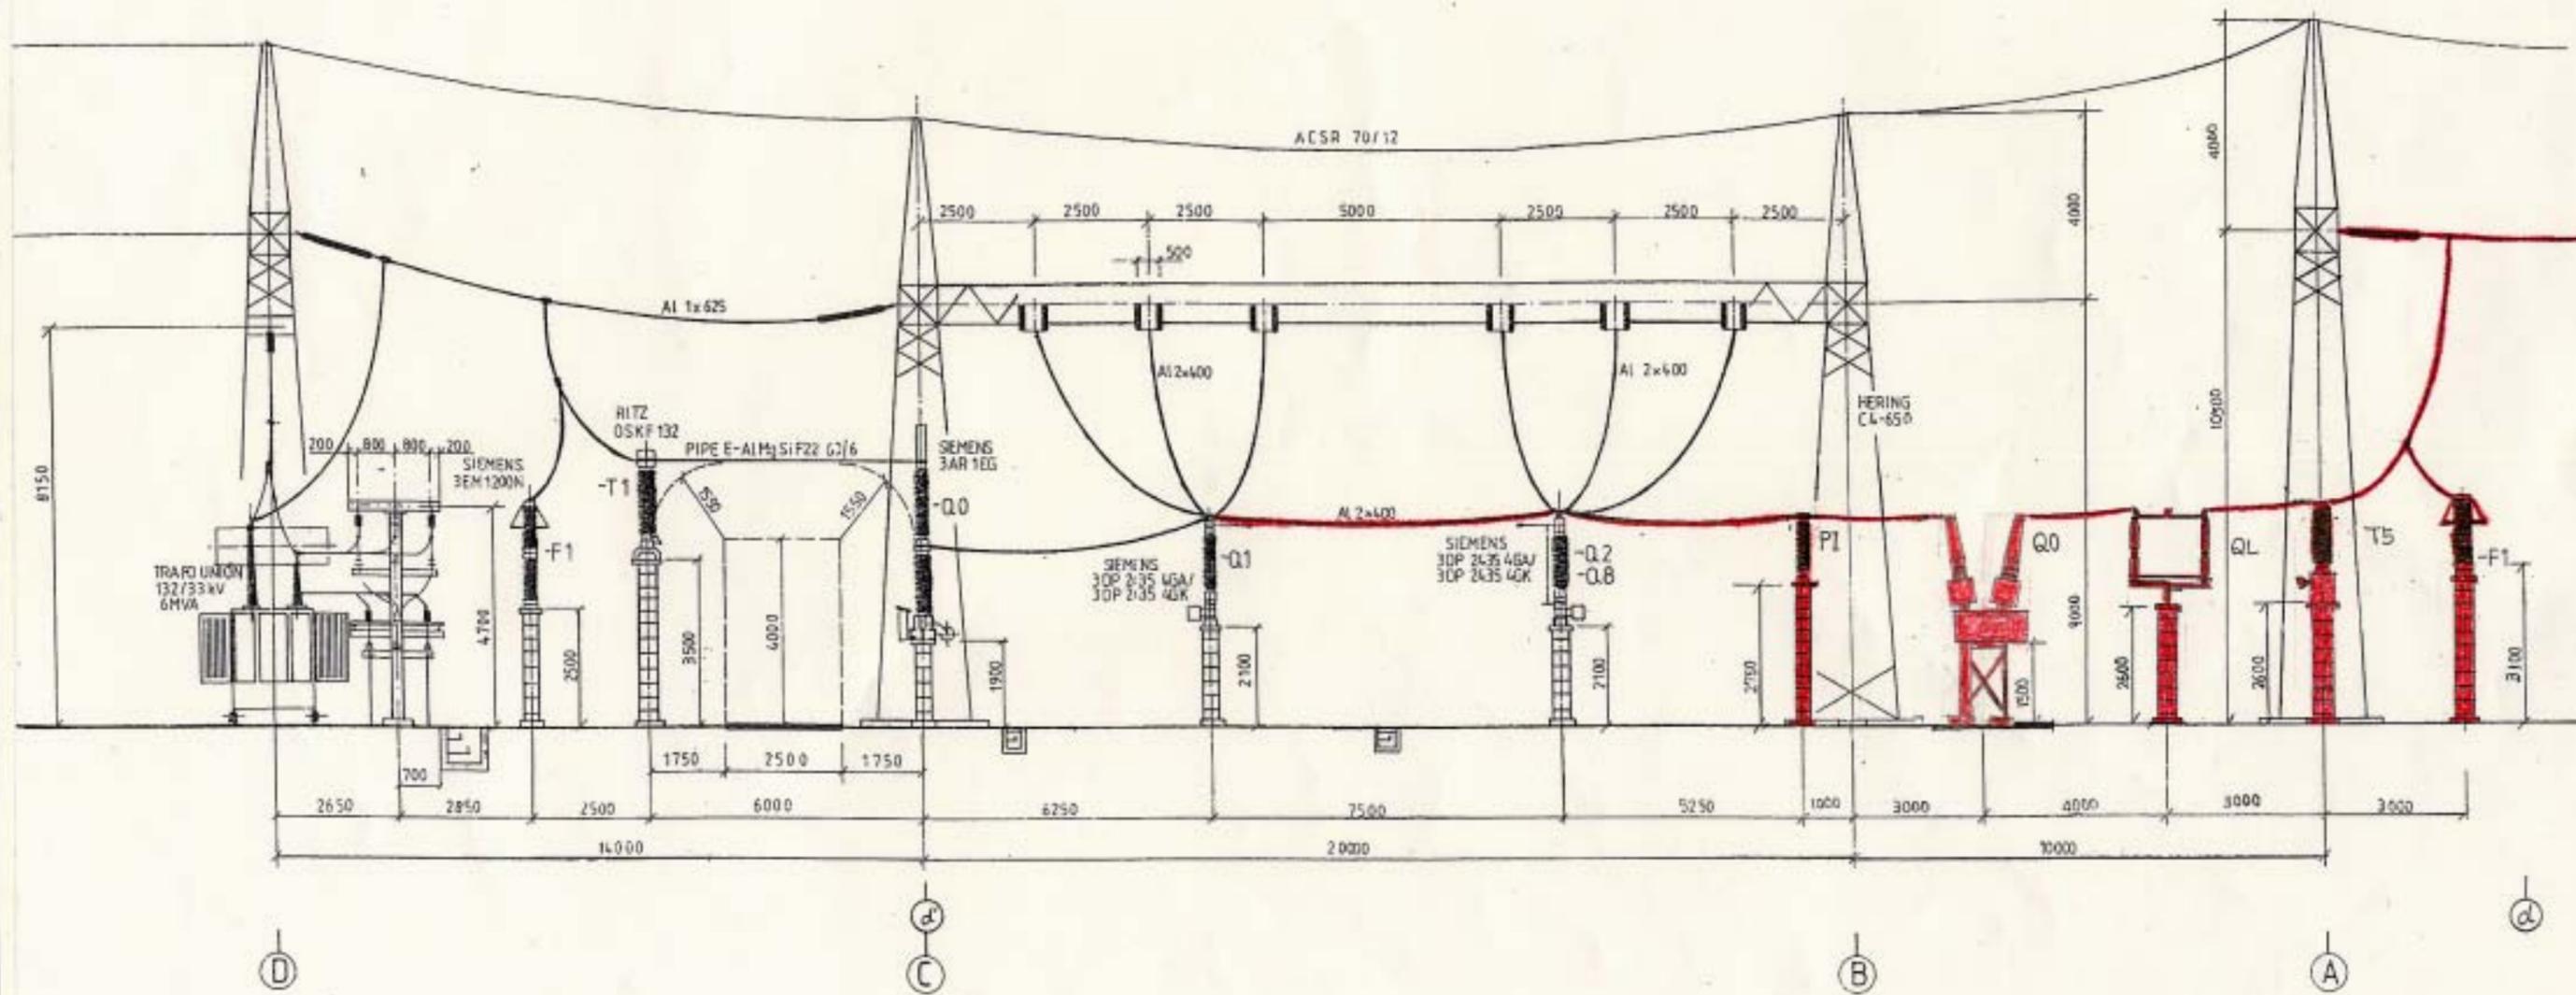

The Project for Rehabilitation of Baluchaung No.2 Hydro Power Plant in the Union of Myanmar			
DWN	<i>Murkin</i>	SCALE	TITLE Elevation of Lawpita 2L of Kalaw Substation
CHKD	<i>N. matan</i>	DATE	
APPD	<i>N. matan</i>	1st October, 2001	DWG No. BAC-TL-0004
NIPPON KOEI CO., LTD. TOKYO ELECTRIC POWER CO., LTD.			

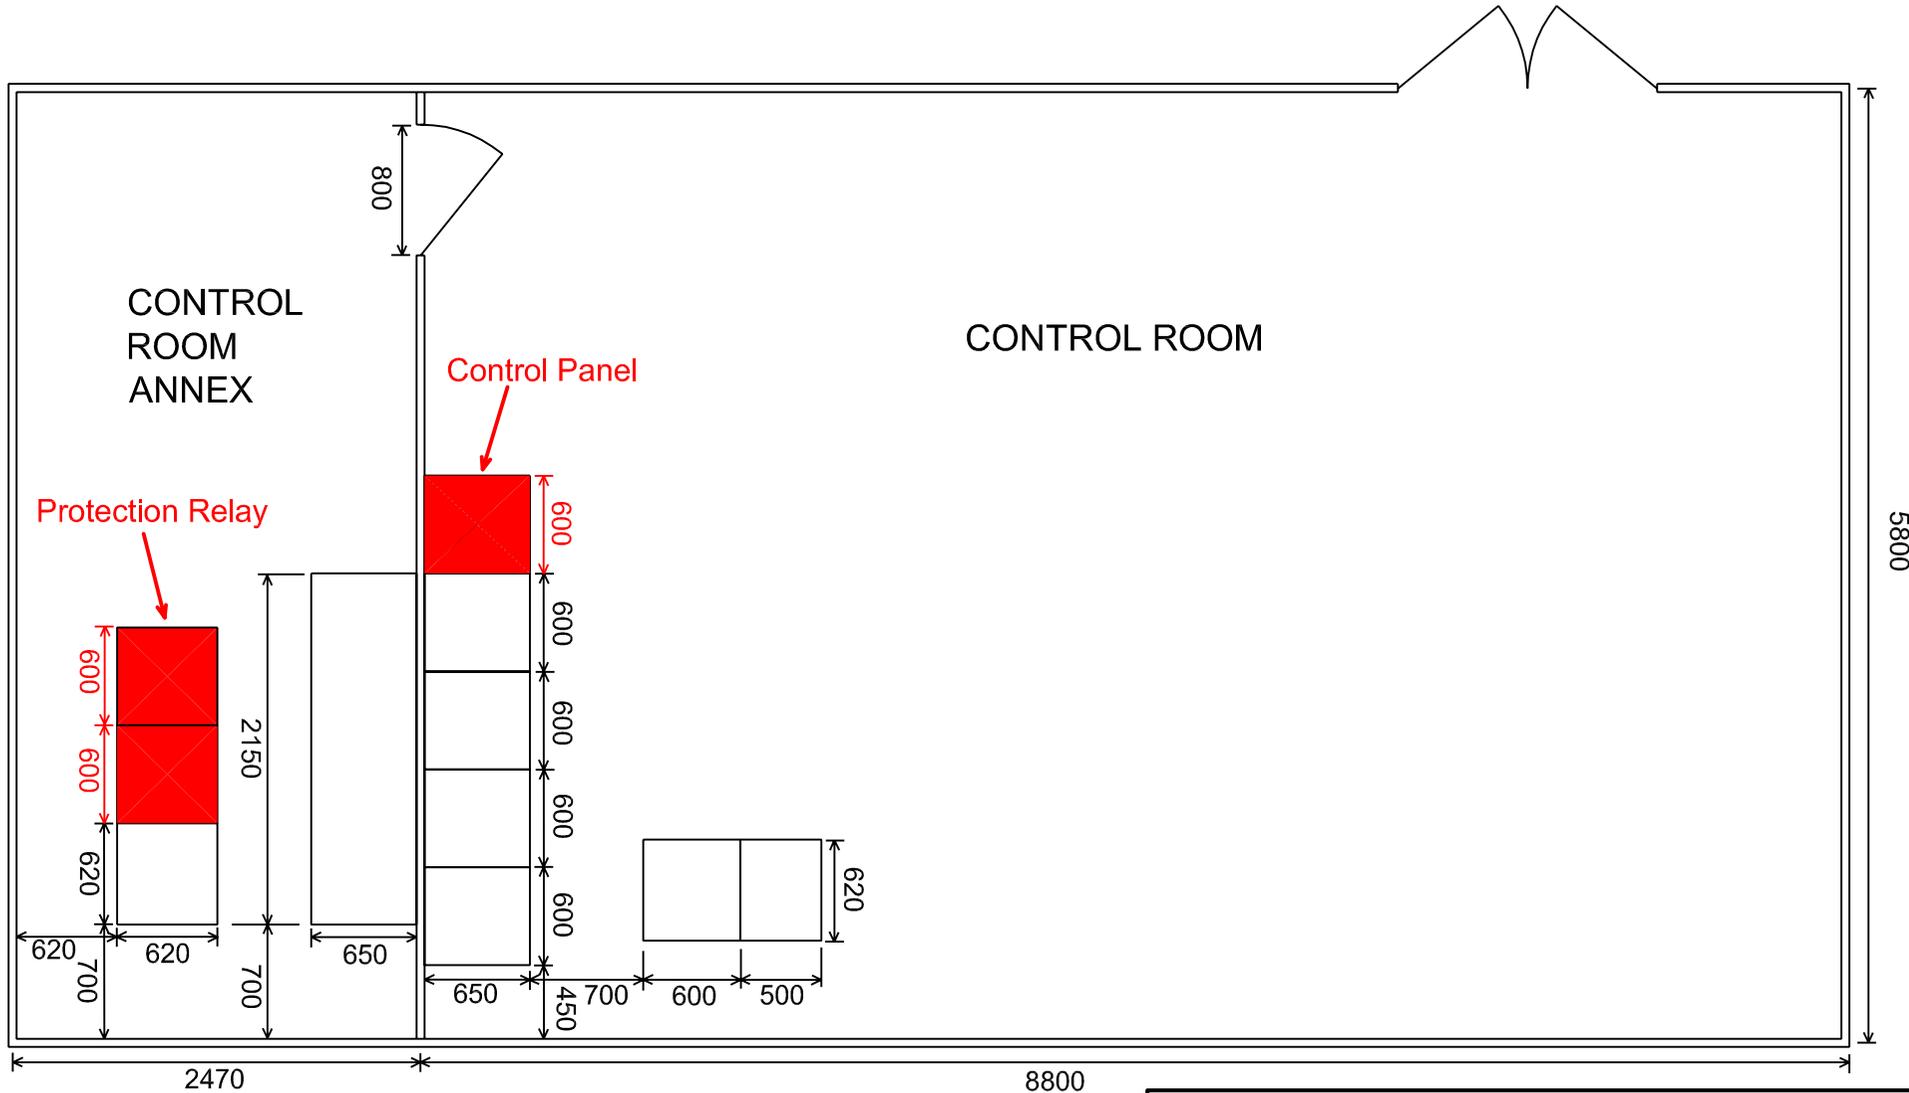

The Project for Rehabilitation of Baluchaung No.2 Hydro Power Plant in the Union of Myanmar			
DWN		SCALE	TITLE
CHKD		DATE	Floor Plan of Control Room of Kalaw Substation
APPD		1st October, 2001	DWG No. BAC-TL-0005
NIPPON KOEI CO., LTD. TOKYO ELECTRIC POWER CO., LTD.			

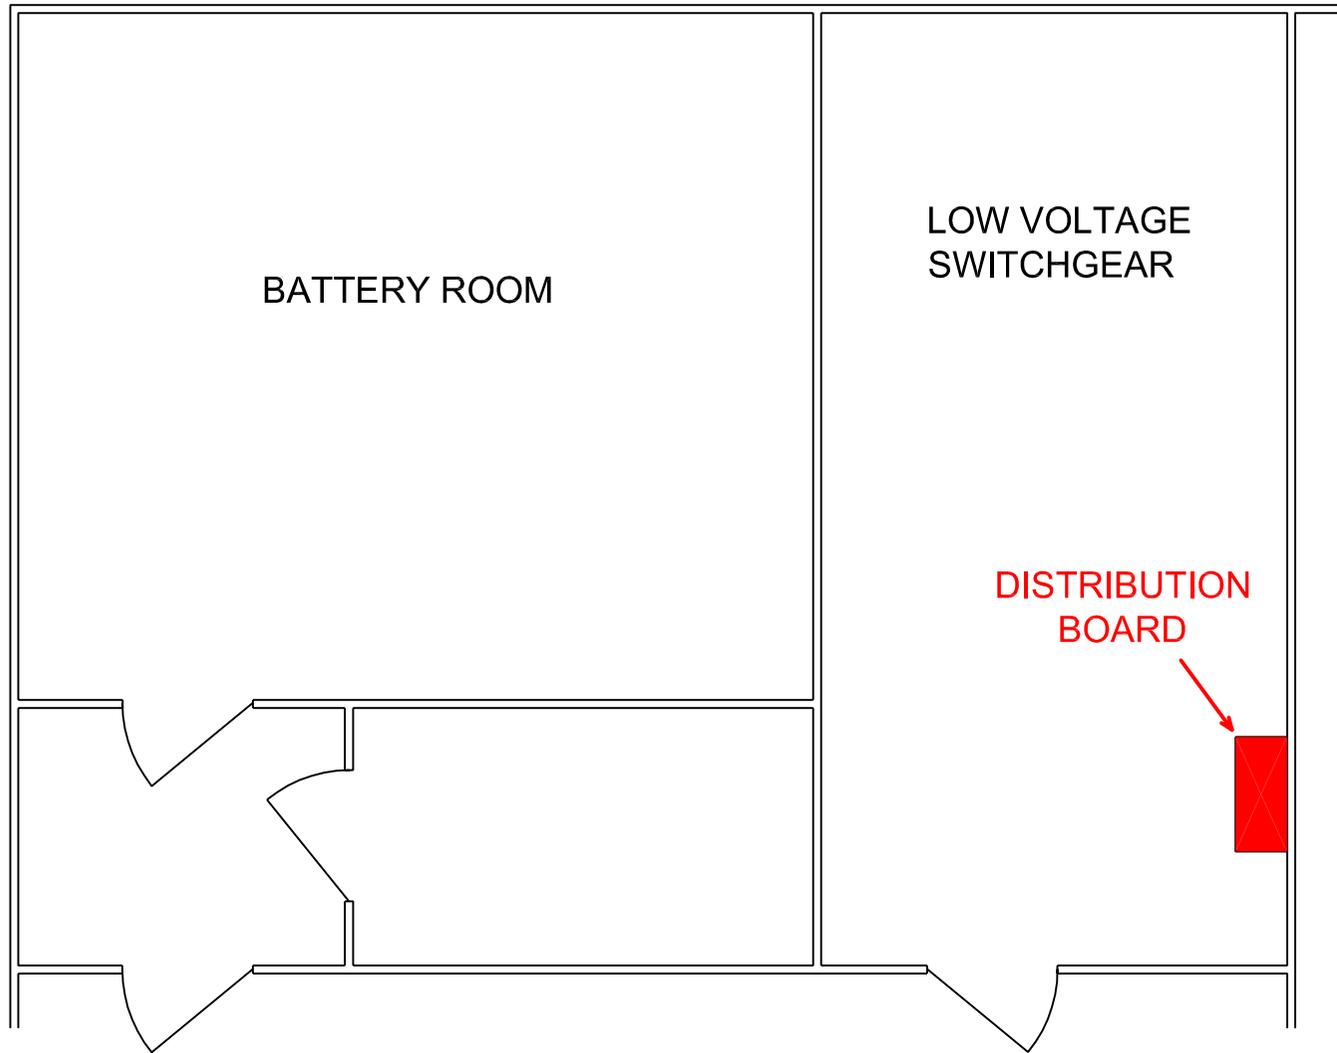

The Project for Rehabilitation of Baluchaung No.2 Hydro Power Plant in the Union of Myanmar			
DWN		SCALE	TITLE
CHKD			Installation Location of Distribution Board of Kalaw Substation
APPD		DATE	
NIPPON KOEI CO., LTD. TOKYO ELECTRIC POWER CO., LTD.		1st October, 2001	DWG No. BAC-TL-0006