社会開発調查部報告書

JAPAN INTERNATIONAL COOPERATION AGENCY (JICA) COMISION EJECUTIVA PORTUARIA AUTONOMA (CEPA)

THE DETAILED DESIGN ON PORT REACTIVATION PROJECT IN LAUNION PROVINCE OF THE REPUBLIC OF EL SALVADOR

FINAL REPORT

(DRAFT) BIDDING DOCUMENTS

Package A: Civil and Building Works Volyme IV-A


DRAWINGS (2/2)



OCTOBER 2002

NIPPON KOEI CO., LTD.

No. 21

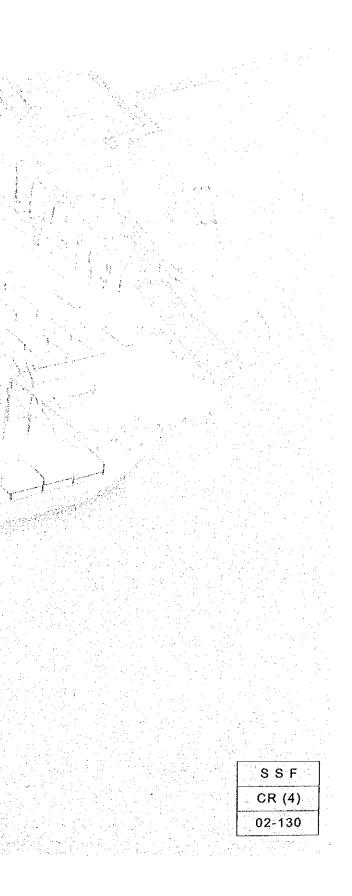

JAPAN INTERNATIONAL COOPERATION AGENCY (JICA) COMISION EJECUTIVA PORTUARIA AUTONOMA (CEPA)

THE DETAILED DESIGN ON PORT REACTIVATION PROJECT IN LA UNION PROVINCE OF THE REPUBLIC OF EL SALVADOR

FINAL REPORT

(DRAFT) BIDDING DOCUMENTS

Package A : Civil and Building Works Volume IV-A


DRAWINGS (2/2)

OCTOBER 2002

 NIPPON KOEI CO., LTD.







LA UNION PORT DEVELOPMENT PROJECT

DRAWING LIST FOR PACKAGE-A (2/2)

BUILDING WORKS

Drawing No.	Title	Drawing No.	Title	Drawing No.	
BUILDING W	ORKS	BD - 01 - 036		BD 01 082	
	GENERAL	BD - 01 - 037	Ramp Details	BD - 01 - 083	Air Conditioning Sy
D - 00 - 001	Building Location Plan	BD - 01 - 038	Miscellaneous Details-01	BD - 01 - 084	Air Conditioning Sy
	General Notes	BD - 01 - 039	Miscellaneous Details-02		Air Conditioning Sy
D - 00 - 003	Architectural Standard Details-01	BD - 01 - 040	Miscellaneous Details-03 (Entrance Canopy Details)		Air Conditioning Sy
D - 00 - 004	Architectural Standard Details-02	***************************************	Miscellaneous Details-04		Air Conditioning Sy
D - 00 - 005	Subsequent Reclamation	BD - 01 - 042	Miscellaneous Detail-05	BD - 01 - 088	Air Conditioning Sy
D - 00 - 006	Structural Standard Details-01		Parking Shed: Floor Plan and Details	BD - 01 - 089	Air Conditioning Sy
D - 00 - 007	Structural Standard Details-02	BD - 01 - 044	Parking Shed: Roof Plan, Sections "A &B" and Details	BD - 01 - 090	Air Conditioning Sy
D - 00 - 008	Electrical Standard Details		Parking Shed Structure Roof, Foundation Plan and Details		Air Conditioning Sy
	PORT ADMINISTRATION BUILDING	BD - 01 - 046	Landscaping Plan	BD 01 092	Air Conditioning Sy
D - 01 - 001	First Floor Plan		Landscape Details		Air Conditioning Sy
D - 01 - 002	Second Floor Plan		Structural Pile Foundation Plan		Panelboard Schedule
	Third Floor Plan	BD - 01 - 049	Structural First Floor Plan	BD - 01 - 095	Panelboard Schedule
	Fourth Floor Plan		Structural Second Floor Pian		Panelboard Schedule
	5th, 6th and Roof Floor Plans		Structural Third Floor Plan	BD - 01 - 097	Panel Board Schedu
	Southwest Elevation		Structural Fourth Floor Plan		Lighting First Floor
	Northeast Elevation	BD - 01 - 053	Structural Fifth, Sixth and Roof Floor Plans		Lighting First Floor
	Northwest Elevation		Structural Section-01 (A Section)		Lighting First Floor
D - 01 - 009			Structural Section-02 (B Section)		Lighting Second Flo
D - 01 - 010	Section A-A		Structural Section-03 (C-Axis Section)		Lighting Third Floor
	Section B-B		Structural Section-04 (4,5 & 6-Axis)		Lighting Fourth Flo
	Section C-C		Structural Section-05 (1,2,3,7 & 8-Axis)		Lighting Fifth and S
	Section D-D		Structural Pile and Column Schedule		Main Stair Case Lig
	Section Details		Structural Foundation Schedule		Outlets First Floor P
	Architectural Counter Details		Structural Foundation Beam Schedule		Outlets First Floor P
	Door and Window Schedule-01		Structure Beam Schedule-01		Outlets First Floor P
	Door and Window Schedule-02		Structure Beam Schedule-02		Outlets Second Floo
	Door and Window Schedule-03		Structural Slab Schedule		Outlets Third Floor
	Exterior and Interior Finish Schedule-01		Canopy Structure Details		Outlets 4th Floor Pla
	Exterior and Interior Finish Schedule-02		Structural RC Details		Outlets 5th and 6th 1
	Finish Plan: First Floor (Part 1)		Structural Stairs Details		Fire Detection Syste
	Finish Plan: First Floor (Part 2)		Water Supply Plumbing Isometric	BD - 01 - 114	Fire Detection Syste
	Finish Plan: First Floor (Part 3)		Wate Drainage Plumbing Isometric	BD - 01 - 115	Fire Detection Syste
	Finish Plan: Second Floor		Sanitary Drainage Plumbing Isometric		Fire Detection Syste
	Finish Plan: Third Floor		Plumbing System and Fire Fighting System, First Floor		Communication Sys
	Finish Plan: Fourth and Fifth Floors		Plumbing System and Fire Fighting System, First Poor		Communication Sys
D - 01 - 020	Finish Plan: Sixth Floor and Roof				Communication Sys
D - 01 - 027 D - 01 - 028	Toilet Detail-01		Phimbing System and Fire Fighting System, Third Floor		Communication Sys
	Toilet Detail-02		Plumbing System and Fire Fighting System, 4th, 5th, 6th Floor		
			Phumbing System Toilet Detail-1	BD - 01 - 121	
	Toilet Detail-03		Plumbing System Toilet Detail-2		
	Toilet Detail-04		Phumbing System Toilet Detail-3		
	Toilet Detail-05		Plumbing System Toilet Detail-4		
	Toilet Detail-06	A second s	Plumbing System Toilet Detail-5		
***************************************	Stair Case Detail-01		Plumbing System Kitchen Detail		
BD - 01 - 035	Stair Detail-02 (Emergency Stair)	BD - 01 - 081	Air Conditioning System Piping Diagram	and the second second	

										and the second
						ABIL	JAPAN INTERNATIONAL COOPERATION AGENCY (JICA)	THE DETAILED DESIGN ON PORT REACTIVATION PROJECT IN LA UNION PROVINCE OF THE REPUBLIC OF EL EALVADOR	DESIGNED BY ; CHECKED BY ;	SECTION : BUILDING SUB-SECTION : DRAWING
REV. NO	DATE	Соокомите	BY	APPROVED	DATE	Gpa	COMISION EJECUTIVA PORTUARIA AUTONOMA (CEPA)	NIPPON KOEI CO., LTD.	APPROVED BY :	nne DRAWING BUILDING
	- DATE			PETROVED	DAIL	<u> </u>			_ L	· · · · · · · · · · · · · · · · · · ·

Title	
System Equipment Schedule-01	
System Equipment Schedule-02	
System Equipment Schedule-03	
System First Floor Plan(Part-1)	
System First Floor Plan(Part-2)	
System First Floor Plan(Part-3)	
System Second Floor Plan	
System Third Floor Plan	
System 4th and 5th Floor Plans	
System 6th and Roof Floor Plans	
System Detail-01	·····
System Detail-02	
ulo-01	
ule-02	
ule-03	**********
dule-04	
or Plan (Part-1)	
or Plan (Part-2)	
or Plan (Pari-3)	·····
loor Plan	
oor Plan	a
loor Plan	
Sixth Floor Plans	
ighting and Outlets	
r Plan (Part-1)	
r Plan (Part-2)	
r Plan (Part-3)	
oor Plan	
or Plan	
Plan	
h Floor Plan	
stem First Floor Plan	
stem Second Floor Plan	
stem Third Floor Plan	
stem 4th, 5th and 6th Floor Plans	
ystem First Floor Plan	
ystem Second Floor Plan	
ystem Third Floor Plan	
ystem 4th, 5th & 6th Floor Plan	
ion System Elevation & Reef Plan	
· · · · · · · · · · · · · · · · · · ·	
· · · ·	
G WORK	DATE : OCTOBER/2002
LIST	SCALE :
G LIST FOR PACKAGE-A	NOT TO SCALE
IG WORKS (1/3)	DRAWING NO:
· -· · · · · · · · · · · · · · · · ·	DL-03-01

LA UNION PORT DEVELOPMENT PROJECT

DRAWING LIST FOR PACKAGE-A (2/2)

BUILDING WORKS

Drawing No.	Title	Drawing No.	Title	Drawing No.	
	CONTAINER FREIGHT STATION (C.F.S)		MAINTENANCE AND REPAIR SHOP		CONTAINER GATE
BD 02 001	First Floor Plan	BD - 03 - 001	First Floor Plan	BD 04 001	First Floor Plan
BD - 02 - 002	Mezzanine Floor Plan	BD - 03 - 002	Mezzanine Floor Plan	BD - 04 - 002	Second Floor Plan
BD - 02 - 003	Roof Plan	BD - 03 - 003	Roof Plan		Roof Plan
3D - 02 - 004	Northwest and Southwest Elevations	BD - 03 - 004	Northwest Elevation, Northeast Elevation		Northwest & Southwest
3D - 02 - 005	Southwest and Northeast Elevations		Southeast Elevation, Southwest Elevation		Southeast & Northeast E
3D - 02 - 006	Section A-A and Section B-B		Section A-A and B-B	······································	Section A-A & B-B
BD - 02 - 007	Section C-C	BD - 03 - 007	Section C-C and D-D	BD - 04 - 007	Detailed Plan of Offices
3D - 02 - 008	Architectural Detail Section-01		Architectural Detailed Section-01		Architectural Detail Sect
3D - 02 - 009	Section Detail -02 and Miscellaneous Details		Architectural Detailed Section-02		Door and Window Schee
ND - 02 - 010	Roll-up Door Details	BD - 03 - 010	Windows and Doors Schedule-01		Exterior and Interior Fin
	Windows and Doors Schedule-01		Windows and Doors Schedule-02		Finish Plan First Floor
	Windows and Doors Schedule-02		Exterior and Interior Finish Schedule		Finish Plan Second Floor
	Exterior and Interior Finish Schedule		Finish Plan First Floor (Part 1)	***************************************	Steel Stair Detail
	Finish Plan First Floor (part I)		Finish Plan First Floor (Part 2) and Second Floor		Miscellaneous Detail
	Finish Plan First Floor (part II) and Mezzanine Floor Plan		Toilet Detail		Weigh Bridge Detail
*******	Toilet Detail		Staircase Detail		Structural Pile Foundation
	Stair Case Detail		Details of Inspection Pit		Structural First Floor Pla
	Structural Pile Foundation Plan		Washing Ramp Details		Structural Second Floor
***************************************	Structure First and Second Plan		Roll-up Door Detail		
	Structural Roof Plan	and the second	Structural Pile Foundation Plan		Structural Roof Plan
	Skylight Roof Plan and Section-01				Structural Section
	Structural Section-02		Structural First and Second Plans Structural Roof Plan		Structural Pile and Found
	Structural Section-02				Structural Foundation Be
~~	Structural Section-04		Skylight Roof Plan and Structural Section-01 Structural Section-02		Structural Column and B
	Structural Pile and Foundation Schedule		Structural Section-02		Structural Steel Detail-01
		1			Structural Steel Detail-0
	Structure Foundation Beam, Column, Beam and Slab Schedule		Structure Pile and Foundation Schedule		Fire Fighting System, Fi
~~~~	Structure RC Detail		Structure Foundation Beam, Column, Beam and Slab Schedule		Air Conditioning System
V20	Structure Steel Detail-01 Structure Steel Detail-02		Structural RC Detail		Air Conditioning System
			Structural Steel Detail		Panelboard Schedule
	Plumbing System Isometrics		Plumbing System Isometrics		Lighting Plan First Floor
· · · · · · · · · · · · · · · · · · ·	Plumbing System and Fire Fighting System Layout		Plumbing System and Fire Fighting System Layout First Floor		Lighting Plan Second Flo
	Plumbing System Toilet and Kitchen Detail		Fire Fighting System Second Floor, Plumbing Details		Outlets First and Second
	Air Conditioning 1st and Mezzanine Floor & Elevation		Plumbing System Toilet Detail	BD - 04 - 033	Fire Detection System Fi
	Panelboard Schedule		Air-Conditioning System 1st and Mezzanine Floor Plans and Elevation		
	Lighting 1st and Mezzanine Floor Plans		Panelboard Schedule	BD - 04 - 035	Lightning Protection Sys
$\frac{10}{10} = \frac{10}{10} = \frac{10}{10}$	Outlet Plan 1st and Mezzanine Floor		Lighting 1st & Mezzanine Floor Plans		
3D - 02 - 037	Fire Detection System First Floor and Mezzanine Plans		Outlets 1st & Mezzanine Floor Plans		
	Communication System 1st and Mezzanine Floor Plans	where we are all of the second states and states a second states and	Fire Detection System 1st & Mezzanine Floor Plan		
3D - 02 - 039	Lightning Protection System Elevation & Roof Plan		Communication System 1st & Mezzanine Floor Plan		
		BD - 03 - 040	Lightning Protection System Elevation & Roof Plan		
· · · · · · · · · · · · · · · · · · ·					· · · ·
					······
				· ·	•
·····					
			N INTERNATIONAL ON PORT REACTIVATION PROJECT	ED 8Y :	ECTION : BUILDING WOR
	/ · · · · · · · · · · · · · · · · · · ·	LINE COOP		ED BY:	DE-SECTION : DRAWING LIST
				· · ·	<ul> <li>A second sec second second sec</li></ul>
DATE	COORDSATE BY APPROVED DATE	<b>Gpa</b> PORTU	SION EJECUTIVA JARIA AUTONOMA (CEPA) NIPPON KOEI CO., LTD.	YED BY :	DRAWING LIS BUILDING WO

BY APPROVED DATE

Title	
E	
vest Elevations	·
st Elevations .	
ices Section-01	
chedule	
Finish Schedule	
Or	
loor	
lation Plan	
Plan oor Plan & Stair Landing Plan	
oundation Schedule	
n Beam and Slab Schedule nd Beam schedule	
il-01	
ul-02 and RC Detail	
, First and Second Floors	
stem 1st Floor Plan and Elevation stem 2nd Floor Plan and Elevation	
la de la companya de	
loor	
l Floor ond Floor Plans	
n First and Second Floor Plans	
em First and Second Floor Plan	
System Elevation & Roof Plan	
······································	
· · · · · · · · · · · · · · · · · · ·	·
· · · · · · · · · · · · · · · · · · ·	
ORK	DATE : OCTOBER/2002
IST	SCALE : NOT TO SCALE
LIST FOR PACKAGE-A WORK (2/3)	DRAWING KO:
	0L-03-02

#### LA UNION PORT DEVELOPMENT PROJECT

#### DRAWING LIST FOR PACKAGE-A (2/2)

#### **BUILDING WORKS**

Drawing No.	Title	Drawing No.	Title	Drawing No.	
	CARGO GATE		POWER SUPPLY STATION		······································
BD - 05 - 001	First & Second Floor Plans	BD - 06 - 001	First Floor and Roof Plan		
BD - 05 - 002		BD - 06 - 002	Northwest, Northeast, Southeast and Southwest Elevations		e de la companya
BD - 05 - 003	Roof Plan and Section A-A & B-B	BD - 06 - 003	Section A-A, B-B and C-C		
BD - 05 - 004	Detailed Plan of Offices		Architectural Detail Section		
BD - 05 - 005		BD - 06 - 005	Windows and Doors Schedule		·
BD - 05 - 006	Door and Window Schedule	BD - 06 - 006	Exterior and Interior Finish Schedule		
BD 05 007	Exterior and Interior Finish Schedule	BD - 06 - 007	Finish Plan First Floor		***
BD - 05 - 008			Equipment Layout (1)		
BD - 05 - 009			Equipment Layout (2)		
BD - 05 - 010	Miscellaneous Detail		Gate and Fence Detail	· · · · · · · · · · · · · · · · · · ·	
BD - 05 - 011	Weigh Bridge Detail		Miscellaneous Details		
BD - 05 - 012			Structural Pile and Foundation Plan		
BD - 05 - 013	· · · · · · · · · · · · · · · · · · ·		Structural Roof Plan		
BD 05 014	· · · · · · · · · · · · · · · · · · ·	BD - 06 - 014			
	Structural Roof Plan		Structural Pile and Foundation Schedule		
BD - 05 - 016			Structural Beam, Column and Slab Schedule		
BD = 05 = 010 BD = 05 = 017			Plumbing System and Fire Fighting System		
BD - 05 - 018			VAC System 1st Floor Plan, Elevation and Section A-A		
BD - 05 - 019		BD - 06 - 019	Panelboard Schedule		
BD - 05 - 020		BD - 06 - 020	Lighting Plan		
BD - 05 - 021	Structural Steel Detail-02 and RC Detail	BD - 06 - 021	Fire Detection System		
BD - 05 - 021			Communication System		
BD - 05 - 022			Lightning Protection System Elevation & Roof Plan		-
BD - 05 - 024		00 025	Lighting Floteenon System Elevation & Root Fight	n an	· · · · · · · · · · · · · · · · · · ·
BD - 05 - 025					
	Outlet First and Second Floor Plans				
BD - 05 - 020					
	Communication System 1st and 2nd Floor Plan				
BD - 05 - 029					
00 - 023					
			· · · · · · · · · · · · · · · · · · ·	· · · · · · · · · · · · · · · · · · ·	
			· · · · · · · · · · · · · · · · · · ·		
			· · · · · · · · · · · · · · · · · · ·		
					······
L		J	1	<u> </u>	1
					,
<u> </u>			THE DETAILED DESIGN	deskned by :	SECTION : BUILDING
			N INTERNATIONAL ERATION AGENCY IN LA UNION PROVINCE		- PUITTIAG
			(JICA) IN LA UNION PROVINCE OF THE REPUBLIC OF EL SALVADOR	CHECKED BY :	SUB-SECTION : DRAWING
		COMI	SION EJECUTIVA JARIA AUTONOMA NIPPON KOEL CO., LTD.		TILE · DRAWING
		GPA PORTI	JARIA AUTONOMA (CEPA) NIPPON KOEI CO., LTD.	APPROVED BY :	BUILDING
NO. DATE	COORDINATE BY APPROVED DATE				

LIST FOR PACKAGE-A G WORKS (3/3)	DRAWING NO: DL-03-03
LIST	scale : NOT TO SCALE
WORK	DATE : OCTOBER/2002
· · · · · · · · · · · · · · · · · · ·	······
	· •
	· · · · · · · · · · · · · · · · · · ·
• • • • • • • • • • • • • • • • • • •	
	· · · · · · · · · · · · · · · · · · ·
	****
Title	······································
<ul> <li>A second s</li></ul>	

#### T & TINDAN BODT DEVELOBMENT DOOTFOT

Drawing No.	Title	Drawing No.	and the second second	Title	Drawing No.	
UTILITY WO	PKS			······		
	WASTEWATER SYSTEM	· .				
	General Layout of Wastewater System					
	Detail-1 of Wastewater System					
	Detail-2 of Wastewater System					
	Details of Oil/Water Separator - 1 (M&R Shop)					
	Details of Oil/Water Separator - 2 (Storm Water Route-A)					
	Details of Oil/Water Separator - 3 (Storm Water Route-B)					
	Details of Oil/Water Separator - 4 (Storm Water Route-C)		· ····································			
	Details of Oil/Water Separator - 5 (Storm Water Route D)					
	WATER SUPPLY AND FIRE FIGHTING SYSTEMS					
***************************************	General Layout of Water Supply and Fire Fighting Systems					
	Layout of Water Supply and Fire Fighting Systems in Port Area			· · · · · · · · · · · · · · · · · · ·		
	Layout of Water Supply and Fire Fighting Systems in Out of Port Area					
	Profile of Water Supply and The righting systems in Out of rate					
	Proposed Location of Water Storage and Purification Facilities					
	Detail-1 of Water Storage Tanks					
	Detail-2 of Water Storage Tanks					
	Detail-1 of Water Supply System					
	Detail-2 of Water Supply System					
	Detail-1 of Fire Fighting System					
	Detail-2 of Fire Fighting System					
	2 Detail-3 of Fire Fighting System				: · · · ·	
01 - 02 - 012	. Ittalies of the righting System					
ELECTRICA	I. WORKS					
ELECTIMUM	GENERAL					
	E.E.O. Transmission Line For La Union Port					
CL - VV - VVI	POWER SUPPLY		· · · · · · · · · · · · · · · · · · ·			
ET 01 001	Power Supply System Single Line Diagram					
	2 46 ky Transmission Line Route 3 Power Supply Station Equipment Layout					
	4 Distribution System Diagram					·
	5 Main Underground Cable Layout					
	AREA LIGHTING SYSTEM					
	ARCA LIGHTING STSTEM					
	2 Details of Lighting Poles, Masts and Fixtures					
	3 Street Light, Area Light Around Administration Building & Details					
<u>EL - V4 - VV</u>	FIRE DETECTION AND COMMUNICATION SYSTEM					
171 02 00						
	1 Fire Detection System Diagram 2 Fire Detection System Layout		· · · · · · · · · · · · · · · · · · ·			Participal and a second state of the second st
	2 Fire Detection System Layout 3 Communication / Data System Diagram					
					······································	
	4 Communication System Layout		······································			
EL - US - 00	5 Mobile Phone & UHF/VHF Communication System Principle Diagram	4			······	
	LIGHTNING PROTECTION SYSTEM					
EL - 04 - 00	I Lightning Protection System Layout			· · · · · · · · · · · · · · · · · · ·		
<u> </u>	1	<b>I</b>			I	
		JAPA	N INTERNATIONAL	THE DETAILED DESIGN	DESIGNED BY :	SECRON : UTILITY
			PERATION AGENCY	ON PORT REACTIVATION PRO IN LA UNION PROVINCE		SUB-SECTION : DRAWING
			HIGHT	OF THE DEPUBLIC OF FL SAU		, DARGIN

REV. NO. DATE

			UTILITY	WORKS				
				an an an an tha an an an Ara. An an				
Title	D	rawing No.		Title	Drawing	No.	Title	
RKS			1				· · · · · · · · · · · · · · · · · · ·	
WASTEWATER SYSTEM	· · · · · · · · · · · · · · · · · · ·	·····						
General Layout of Wastewater System			······		,,,,,,,,,,,,,,,,,,,,,,,,,,,,,,,,,,,,,,,			
Detail-1 of Wastewater System								
Detail-2 of Wastewater System			·					
Details of Oil/Water Separator - 1 (M&R Sh						······		
Details of Oil/Water Separator - 2 (Storm W								
Details of Oil/Water Separator - 3 (Storm V								
Details of Oil/Water Separator - 4 (Storm V								
Details of Oil/Water Separator - 5 (Storm V								
WATER SUPPLY AND FIRE FIGHTING								
General Layout of Water Supply and Fire F				******				
Layout of Water Supply and Fire Fighting S								
Layout of Water Supply and Fire Fighting S			·····					
Profile of Water Supply Pipe in Out of Port			/					
Proposed Location of Water Storage and Pr	urification Facilities				· · · · · · · · · · · · · · · · · · ·			
Detail-1 of Water Storage Tanks							,	
Detail-2 of Water Storage Tanks						•••••		
8 Detail-1 of Water Supply System								
9 Detail-2 of Water Supply System								
Detail-1 of Fire Fighting System								
1 Detail-2 of Fire Fighting System								
2 Detail-3 of Fire Fighting System								
I NANKO								
LWORKS								
GENERAL								
I E.E.O. Transmission Line For La Union Po POWER SUPPLY	<b>n</b>				······································	······		
1 Power Supply System Single Line Diagram 2 46 ky Transmission Line Route						· · · ·		
	·····							
3 Power Supply Station Equipment Layout								
4 Distribution System Diagram 5 Main Underground Cable Layout								
AREA LIGHTING SYSTEM								
AREA LIGHTING STSTEM								
2 Details of Lighting Poles, Masts and Fixtur	PS						-*	
3 Street Light, Area Light Around Administ								
FIRE DETECTION AND COMMUNICA								
						· · ·		
12 Fire Detection System Layout		1	1. 2		and functions from the state of a second state of the			
32 Communication / Data System Diagram					· · · ·			
4 Communication System Layout						· ·		
05 Mobile Phone & UHF/VHF Communication								
LIGHTNING PROTECTION SYSTEM	σ							
1 Lightning Protection System Layout								
				n 1997 - Maria Maria, ang sang sang 1997 - Sang sang sang sang sang sang sang sang s				
		JAPAN IN COOPERA	TERNATIONAL TION AGENCY	THE DETAILED DESIGN ON PORT REACTIVATION PROJ IN LA UNION PROVINCE	DESIGNED BY :		TY WORKS	OCTOBER
			JICA)	OF THE REPUBLIC OF EL SALV	ADOR CHECKED BY :	SUB-SECTION : DRAW	ING LIST	SCALE : NOT TO
	mum i						•	